COMMERCIAL DEVELOPMENT 4 BAY CAR SERVICE

TAX MAP 4, LOT NUMBER 49 3 DOVER ROAD, ROUTE 108, DURHAM, NH

SHEET INDEX

COVER SHEET

EXISTING CONDITIONS PLAN

DEMOLITION PLAN

SITE & UTILITY PLAN

GRADING AND DRAINAGE PLAN

LANDSCAPE AND LIGHTING PLAN

DETAIL SHEETS

EROSION AND SEDIMENT CONTROL DETAILS

SCHEMATIC PLAN & ELEVATIONS

TROPIC STAR DEVELOPMENT, LLC 321D LAFAYETTE ROAD HAMPTON. NH 03842 (603) 926-7770 **CONTACT: JAMES MITCHELL**

APPLICANT / DEVELOPER

CIVIL ENGINEER / SURVEYOR

JONES & BEACH ENGINEERS, INC. **85 PORTSMOUTH AVENUE** PO BOX 219

STRATHAM, NH 03885 (603) 772-4746

CONTACT: WAYNE MORRILL EMAIL: WMORRILL@JONESANDBEACH.COM

SEWER

WASTEWATER TREATMENT FACILITY 50 PISCATAQUA RD (RT4) DURHAM, NH 03824 (603) 868-8063

ELECTRIC

PUBLIC SERVICE COMPANY OF NEW HAMPSHIRE 74 OLD DOVER ROAD ROCHESTER, NH 03867 (603) 332-4227

TELEPHONE


FAIRPOINT COMMUNICATIONS 1575 GREENLAND ROAD GREENLAND, NH 03840 (603) 427-5525 **CONTACT: JOE CONSIDINE**

TELEPHONE

FAIRPOINT COMMUNICATIONS 100 TRI CITY ROAD SOMERWORTH, NH 03878 ATTN:DAVE KESTNER (603) 743-1114

CABLE TV

COMCAST COMMUNICATION CORPORATION 334-B CALEF HIGHWAY EPPING, NH 03042-2325 (603) 679-5695

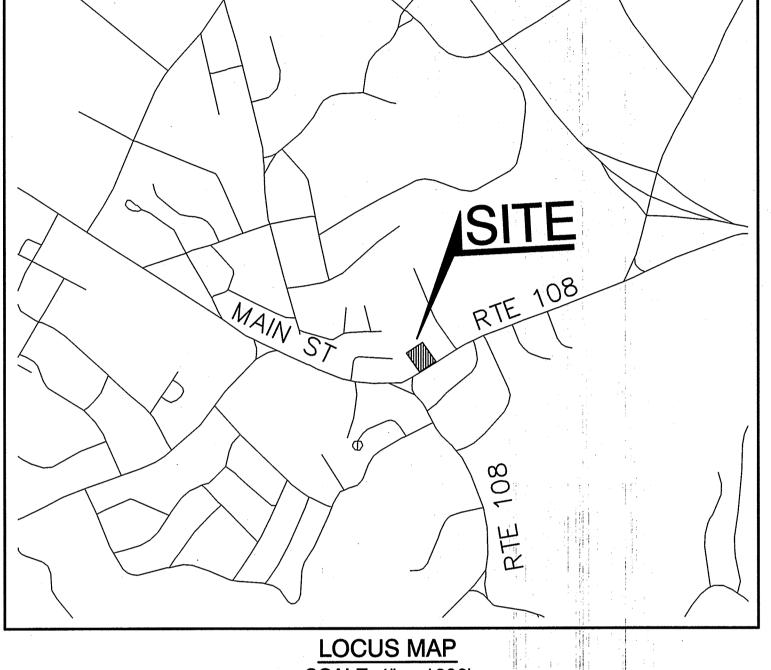

SCALE 1" = 1000'

WATER DEPARTMENT OF PUBLIC WORKS 100 STONE QUARY DRIVE DURHAM, NH 03824

PERMITS

TYPE OF PERMIT

STATUS

USEPA NPDES PHASE II CONSTRUCTION GENERAL PERMIT LOCAL REGULATIONS PRIOR TO AND FOLLOWING CONSTRUCTION: **EPA STORMWATER NOTICE PROCESSING CENTER** MAIL CODE 4203M, 1200 PENNSYLVANIA AVENUE, NW **WASHINGTON, DC 20460**

RESPONSIBLE CONSULTANT: JONES & BEACH ENGINEERS, INC. NEW HAMPSHIRE DEPARTMENT OF TRANSPORTATION, DISTRICT SIX

DURHAM, NEW HAMPSHIRE 03824 (603) 868-1133

RESPONSIBLE CONSULTANT-JONES & BEACH ENGINEERS. INC.

DURHAM SITE PLAN APPROVAL: SUBMITTED:

TOWN OF DURHAM PLANNING BOARD 15 NEWMARKET RD **DURHAM, NEW HAMPSHIRE 03042**

PERMIT NO.

SUBMITTED:

PERMIT NO.

EXPIRATION:

DATED:

DATED: **RESPONSIBLE CONSULTANT:** JONES & BEACH ENGINEERS, INC. **EXPIRATION:**

> PROJECT PARCEL TOWN OF DURHAM TAX MAP 4, LOT 49

OWNER CUMBERLAND FARMS, INC. 100 CROSSING BLVD, V 1015 FRAMINGHAM, MA 01702 BK 1095, PG 35

> TOTAL LOT AREA 11,279 SQ. FT. 0.25 ACRES

VARIANCES GRANTED: JUNE 10,2014

FROM ARTICLE XII, SECTIONS 175-54 AND 175-55(B); AND ARTICLE XXI, SECTIONS 175-111(G)(5), 175-113 AND 175-116(A) OF THE ZONING ORDINANCE TO ALLOW FOR 12 PARKING SPACES FOR A COMMERCIAL PROPERTY WHÈRÉ 16 SPACES WOULD BE REQUIRED, TO ALLOW LESS THAN 5% OF THE PARKING AND DRIVEWAY ARE TO BE LANDSCAPED, TO ALLOW PARKING IN THE REAR YARD, AND TO ALLOW AN ADA PARKING AISLE WITHIN THE FRONT YARD AND A REFUSE CONTAINER WITHIN THE SIDE AND REAR YARDS.

PLANNING BOARD DATE:

APPROVED - DURHAM, NH

Design: BWG Draft: GPC Checked: WGM Scale: AS NOTED Project No.: 14011 Drawing Name: 14011-PLAN.dwg

THIS PLAN SHALL NOT BE MODIFIED WITHOUT WRITTEN PERMISSION FROM JONES & BEACH ENGINEERS, INC. (JBE). ANY ALTERATIONS, AUTHORIZED OR OTHERWISE, SHALL BE AT THE USER'S SOLE RISK AND WITHOUT LIABILITY TO JBE.



		,	
0	08/27/14	ISSUED FOR REVIEW	 GPC
REV.	DATE	REVISION	BY



85 Portsmouth Ave. Civil Engineering Services 603-772-4746 FAX: 603-772-0227 PO Box 219 E-MAIL: JBE@JONESANDBEACH.COM Stratham, NH 03885

Plan Name:

Project:

Applicant:


COVER SHEET


4-BAY CAR SERVICE 3 DOVER ROAD, ROUTE 108, DURHAM, NH


TROPIC STAR DEVELOPMENT, LLC 321D LAFAYETTE ROAD, HAMPTON, NH 03842 SHEET 1 OF 10

JBE PROJECT NO. 14011

DRAWING No.

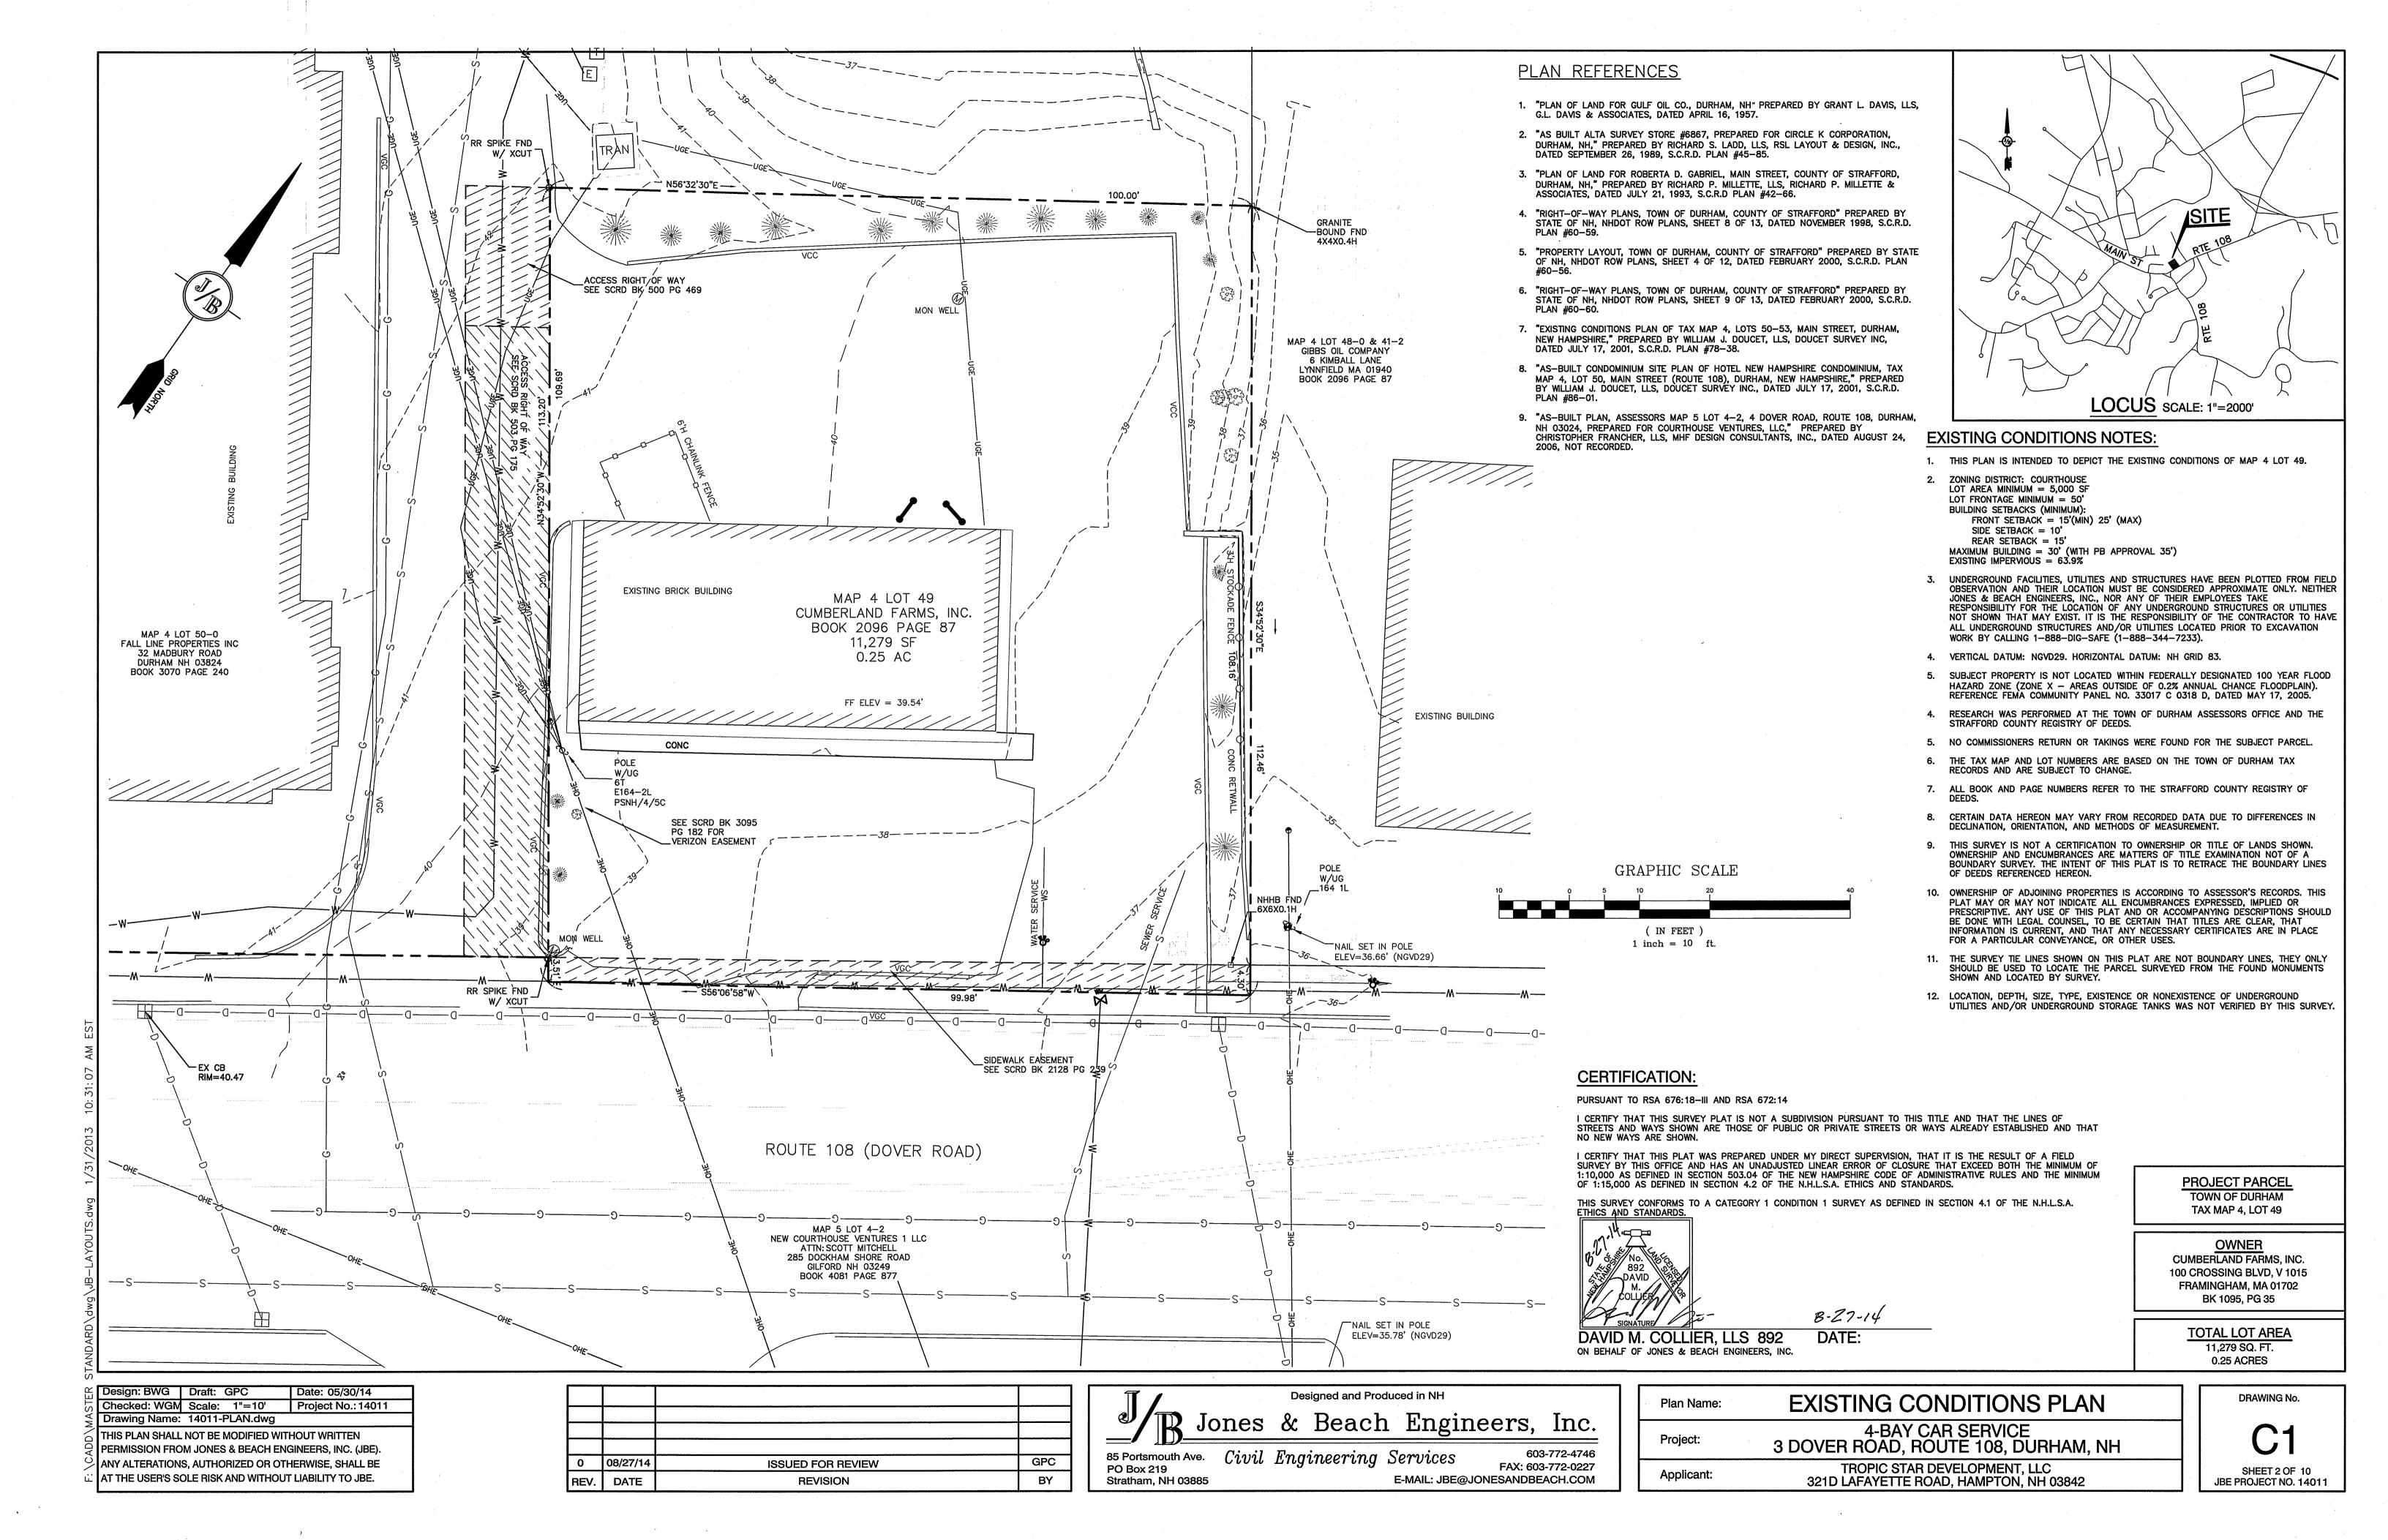

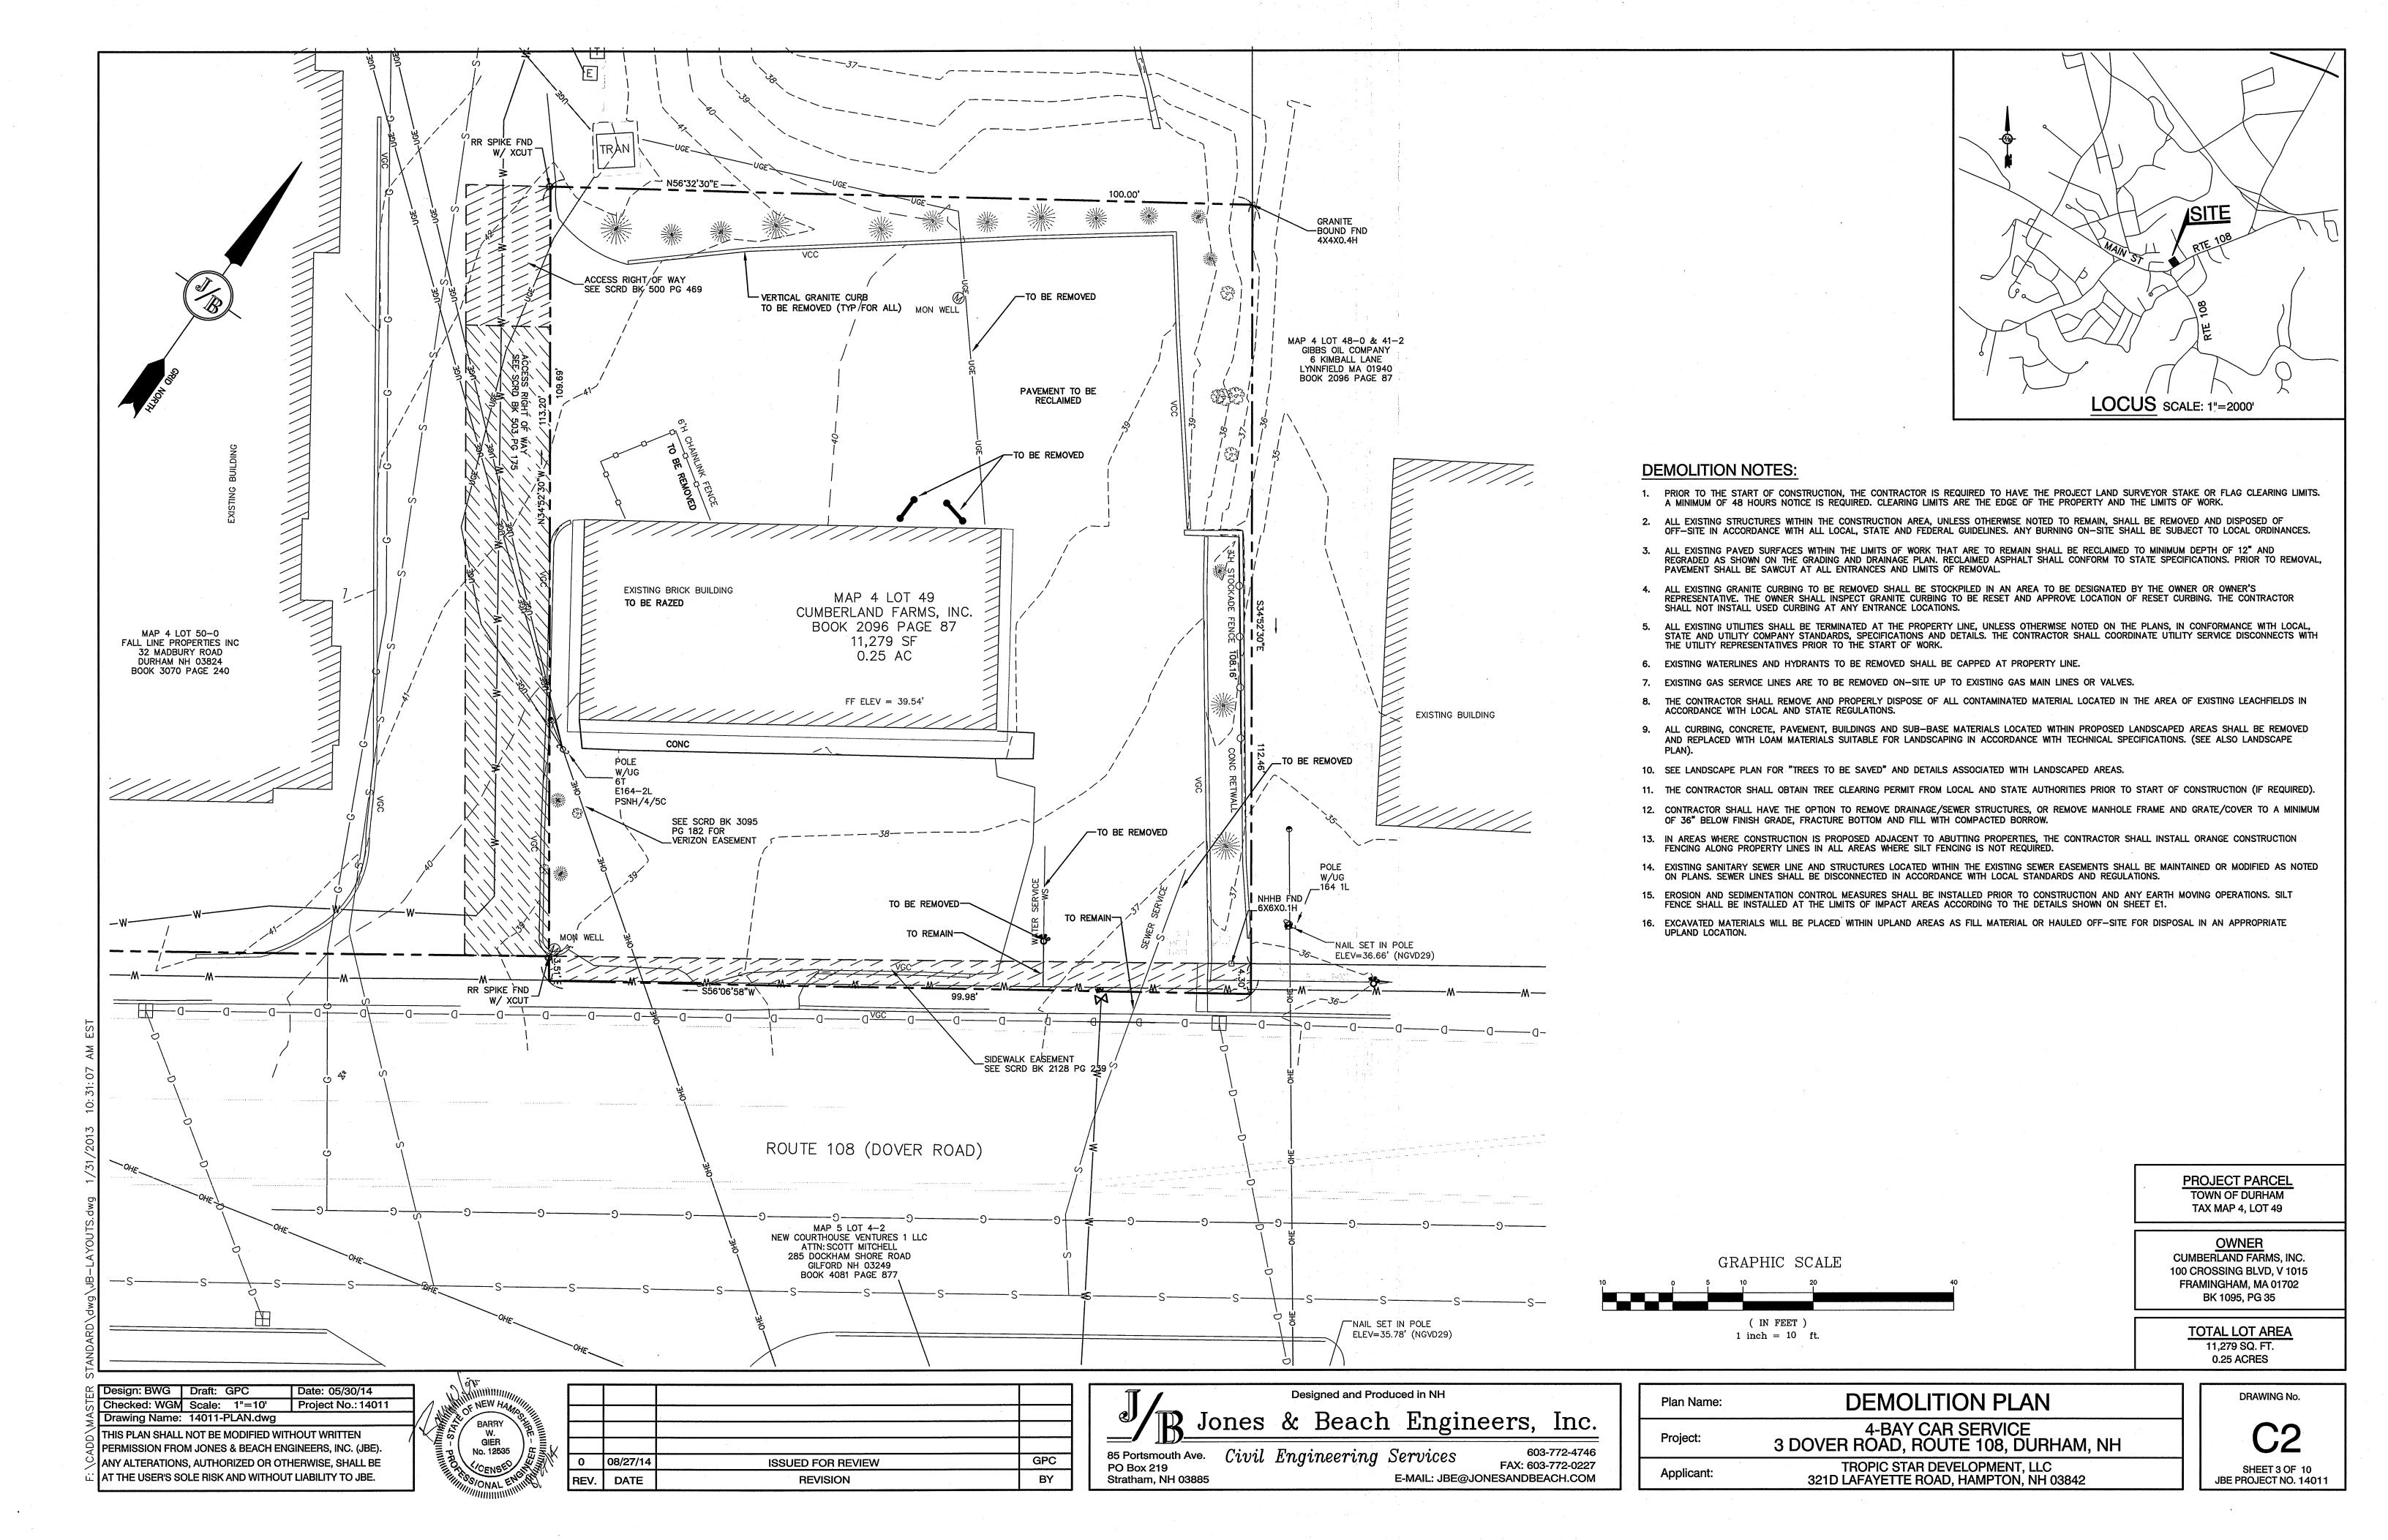

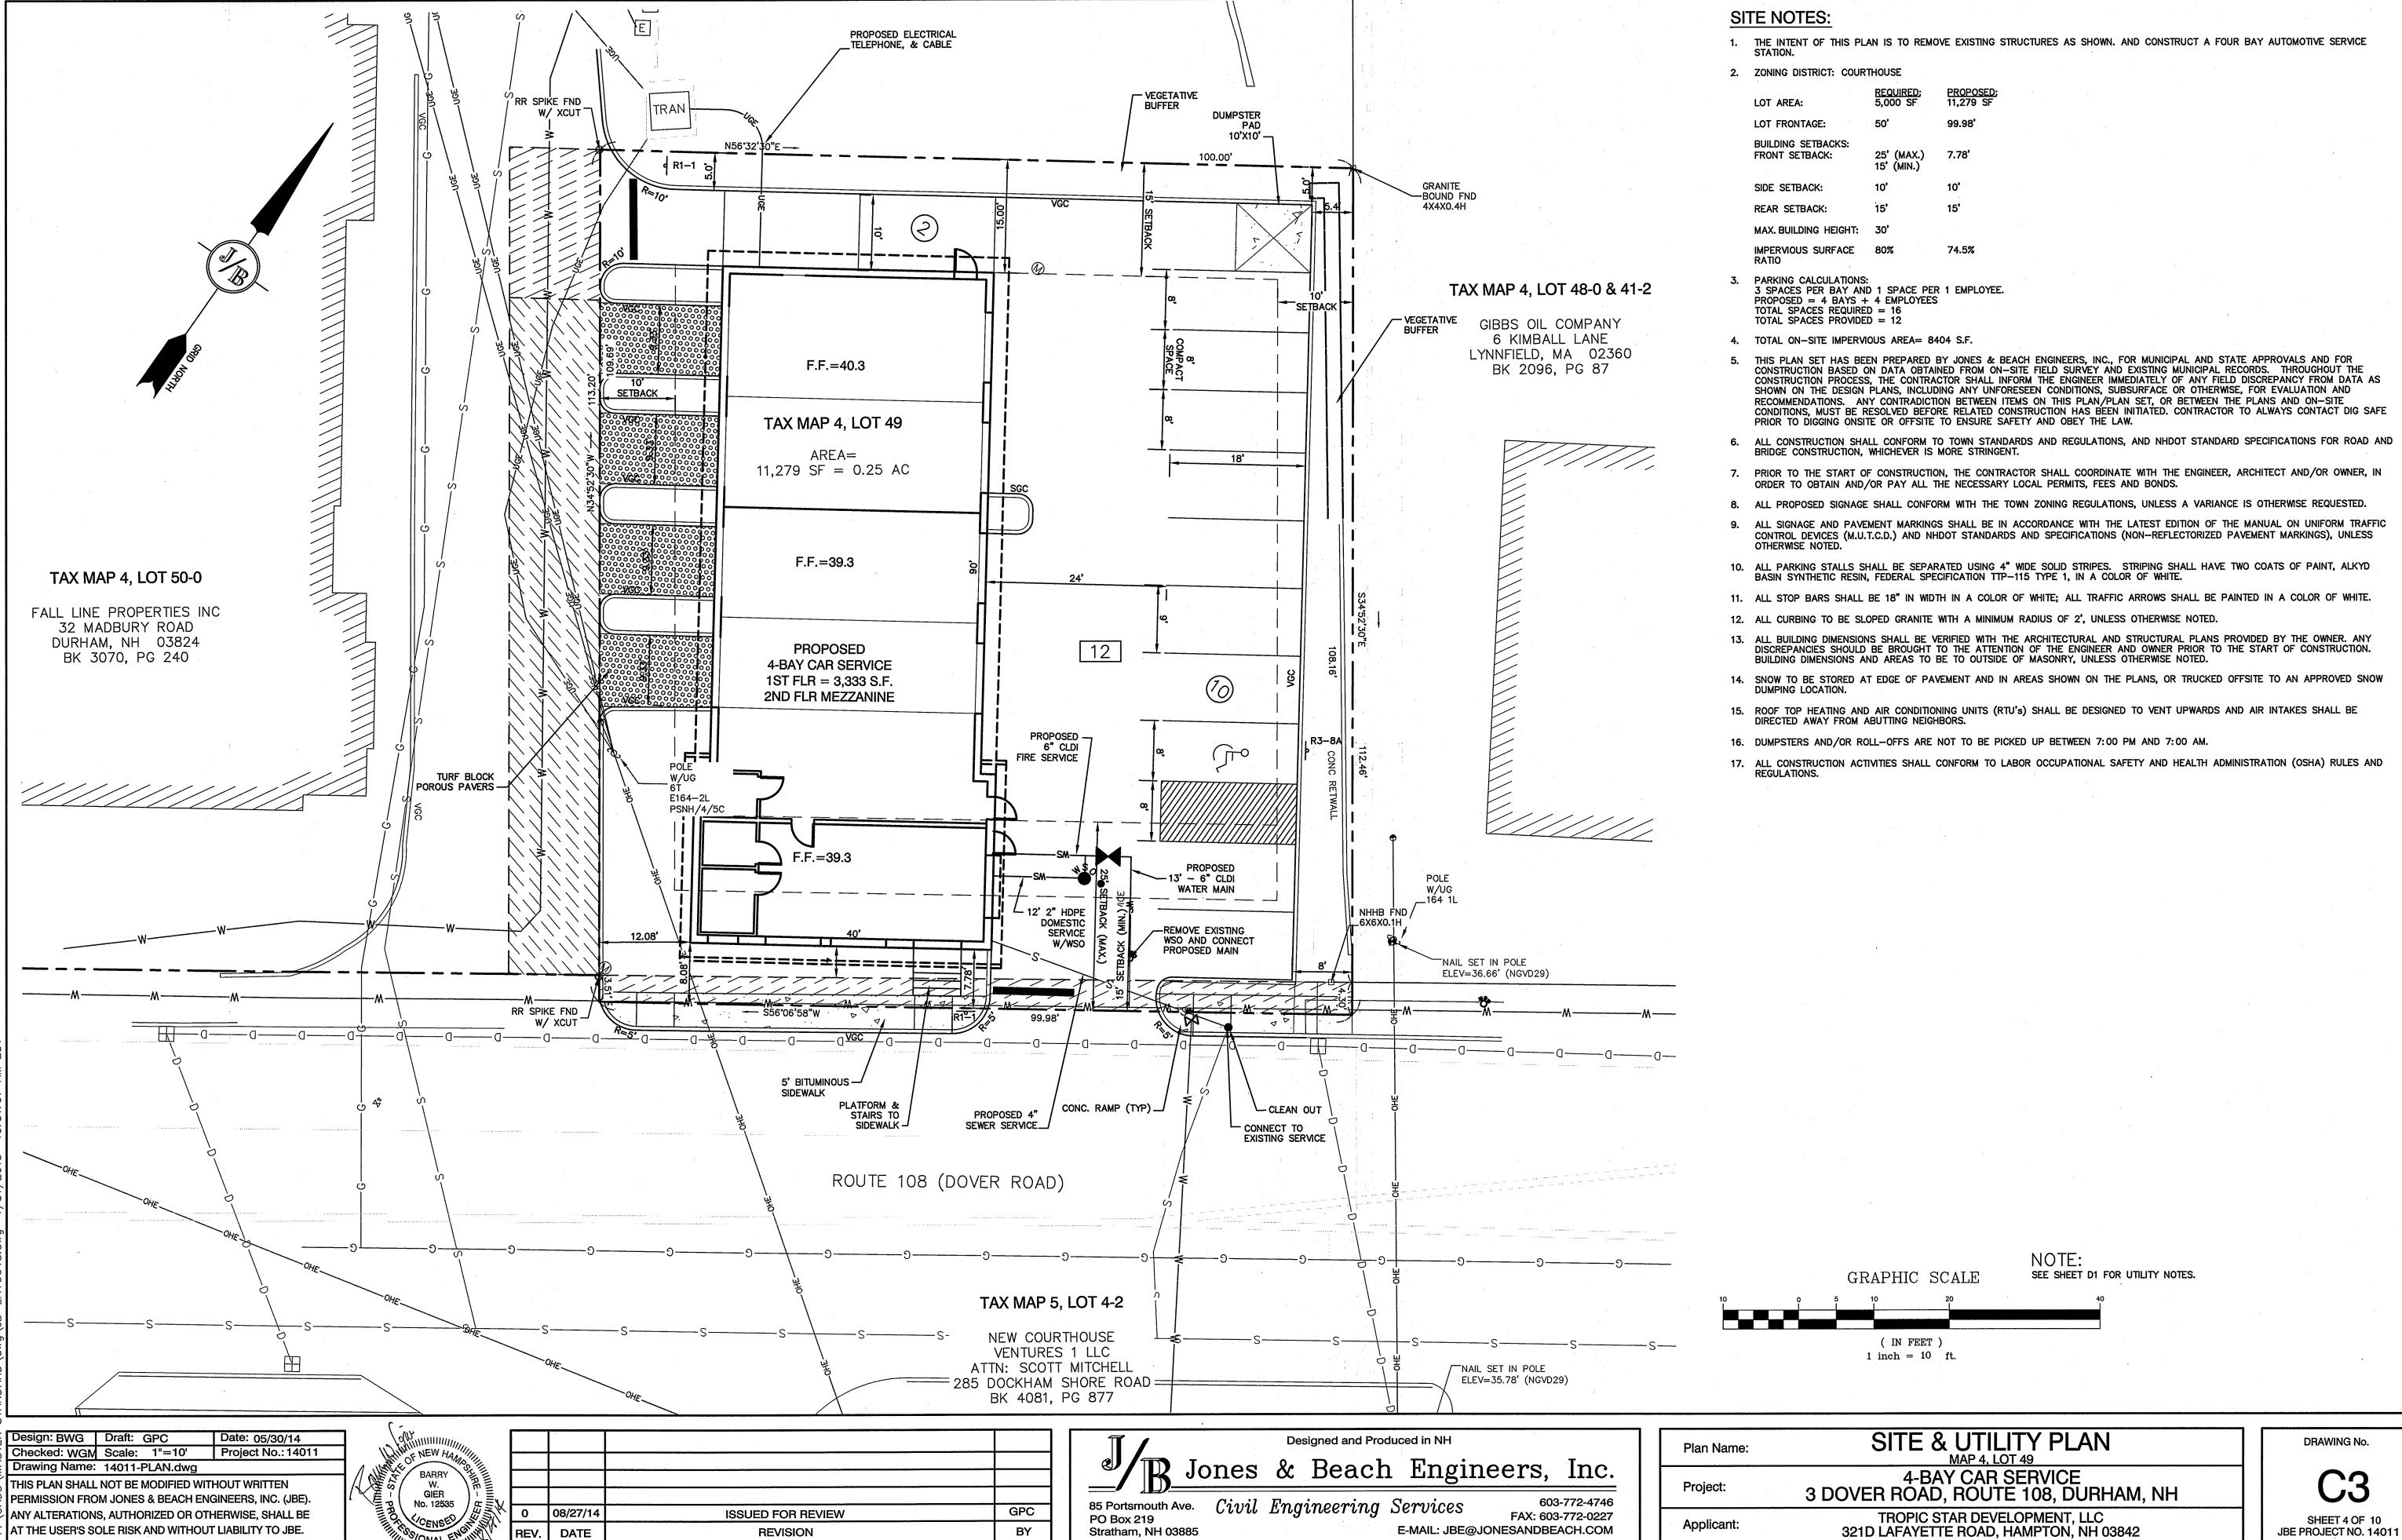


REVISION

BY

Stratham, NH 03885

SHEET 4 OF 10 JBE PROJECT NO. 14011

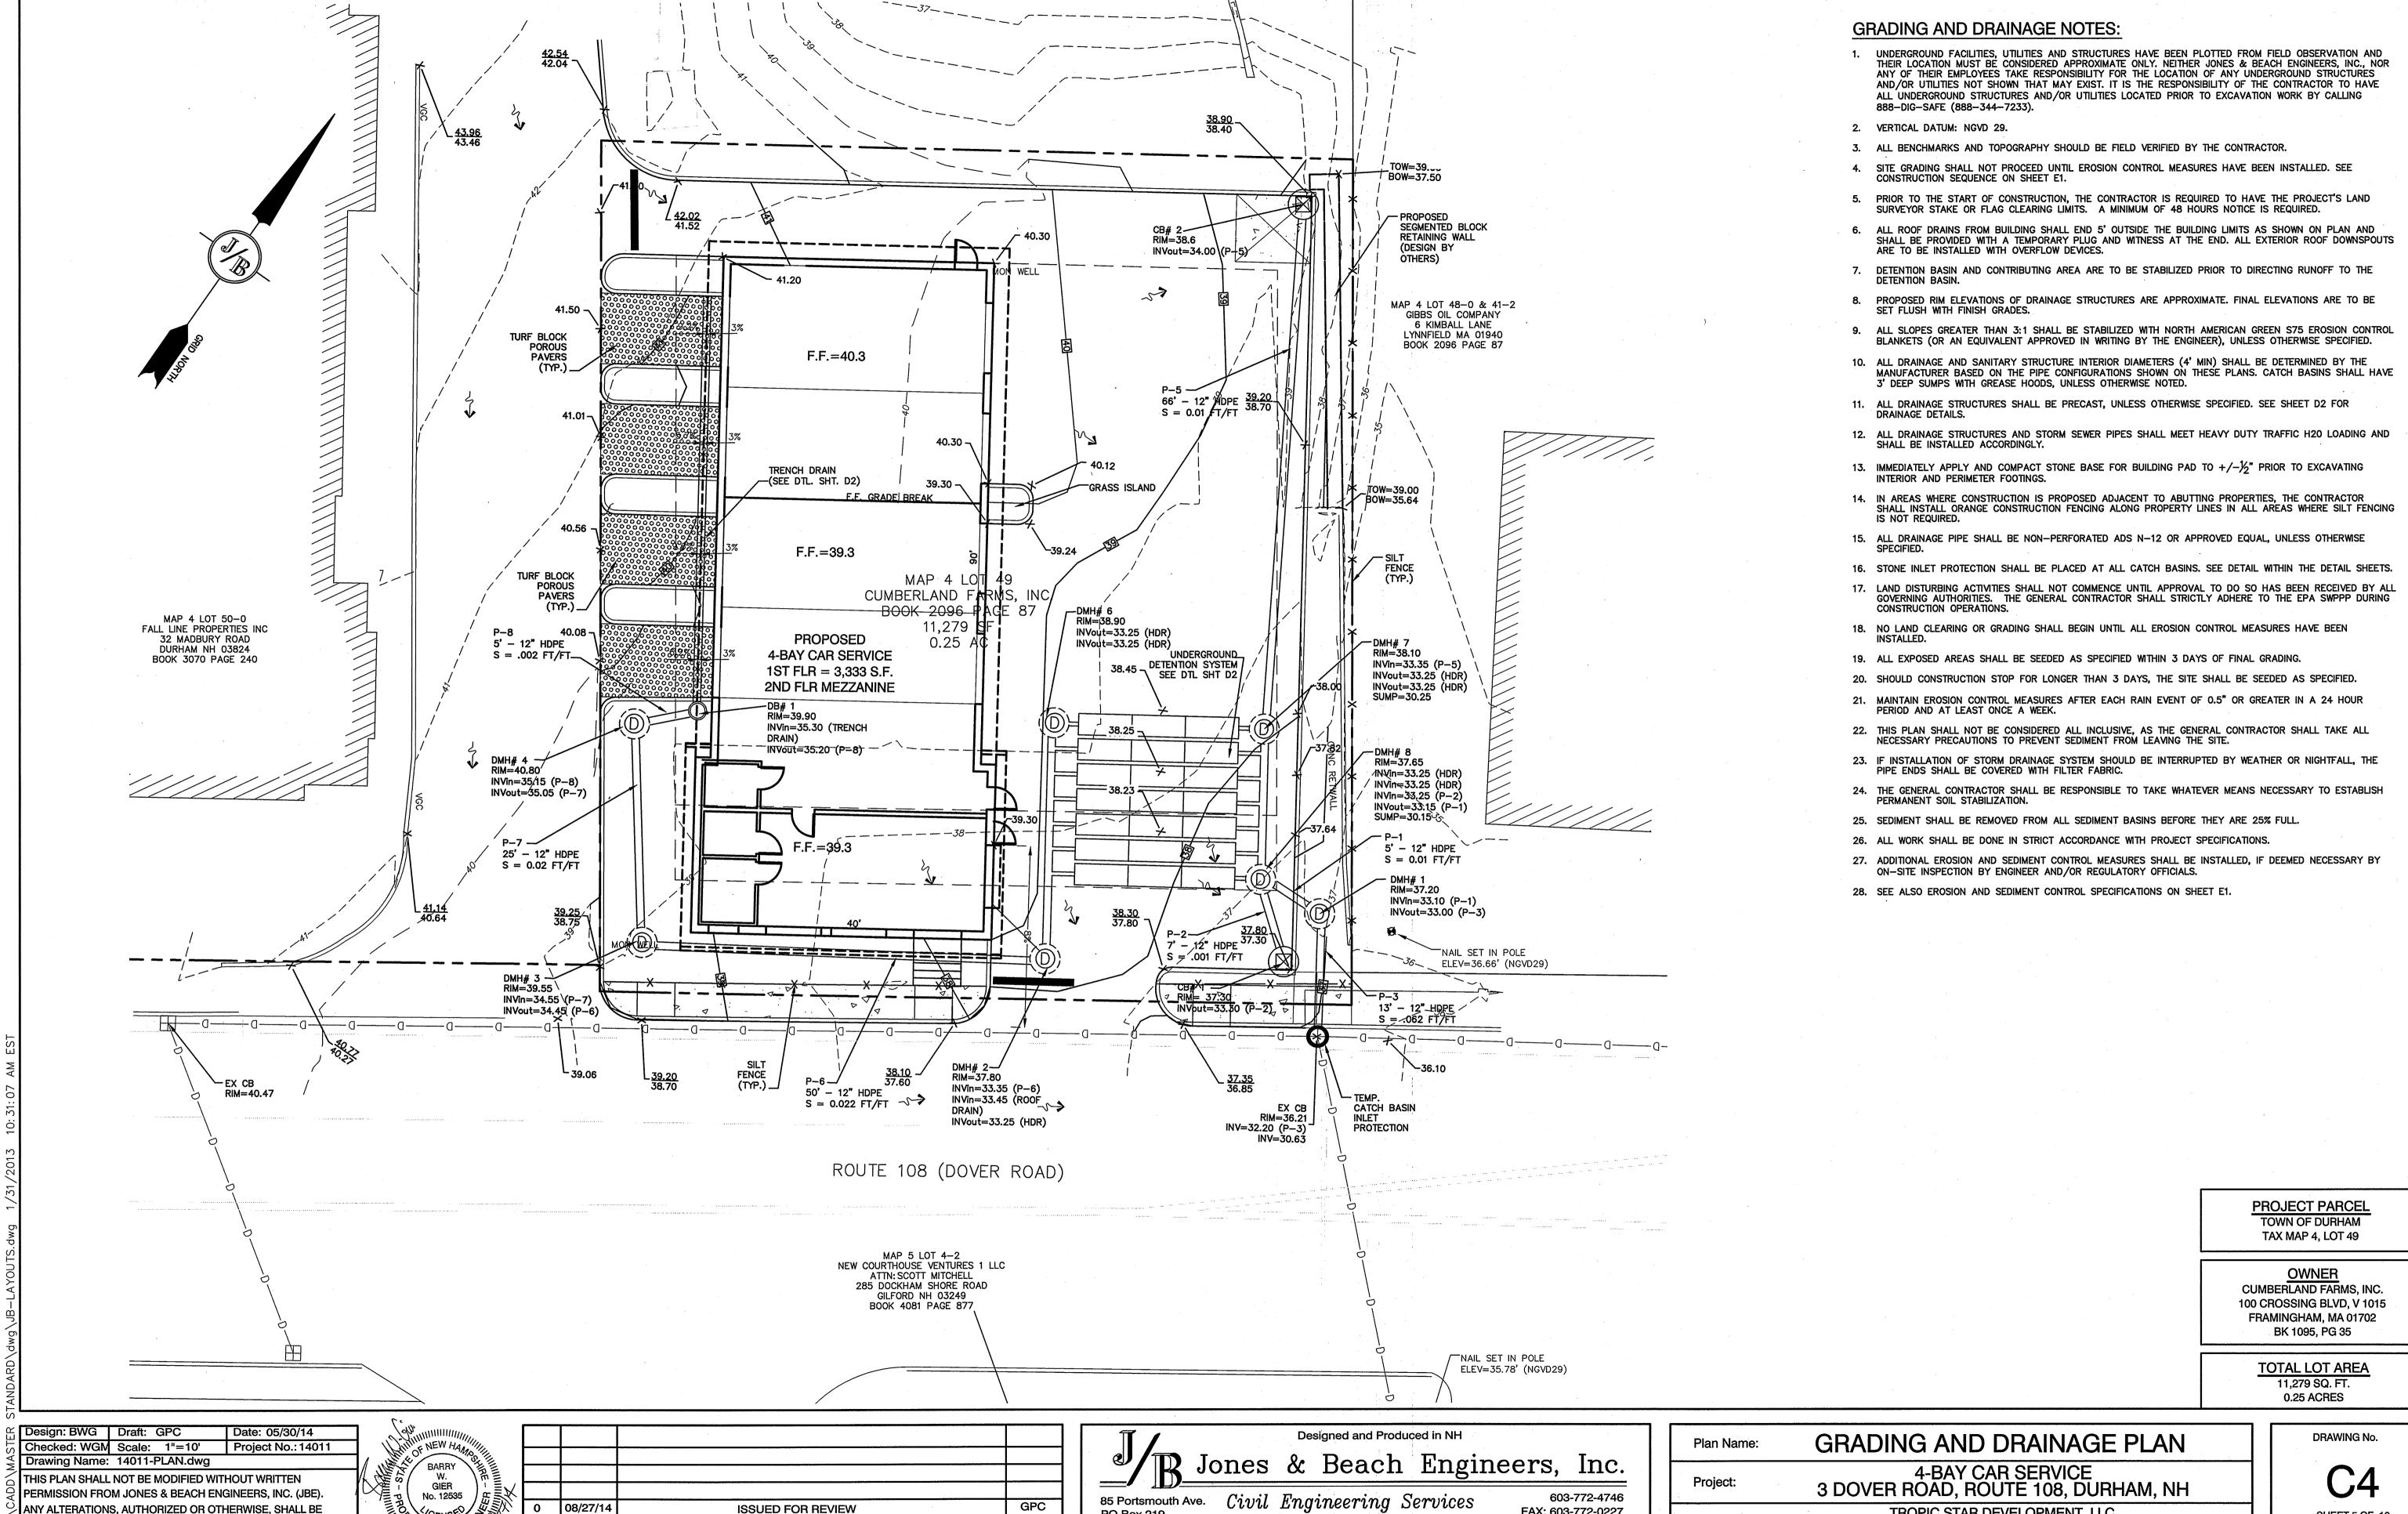

PO Box 219

Stratham, NH 03885

BY

FAX: 603-772-0227

E-MAIL: JBE@JONESANDBEACH.COM

Applicant:

ISSUED FOR REVIEW

REVISION

REV.


DATE


ANY ALTERATIONS, AUTHORIZED OR OTHERWISE, SHALL BE


AT THE USER'S SOLE RISK AND WITHOUT LIABILITY TO JBE.

SHEET 5 OF 10 JBE PROJECT NO. 14011


TROPIC STAR DEVELOPMENT, LLC 321D LAFAYETTE ROAD, HAMPTON, NH 03842

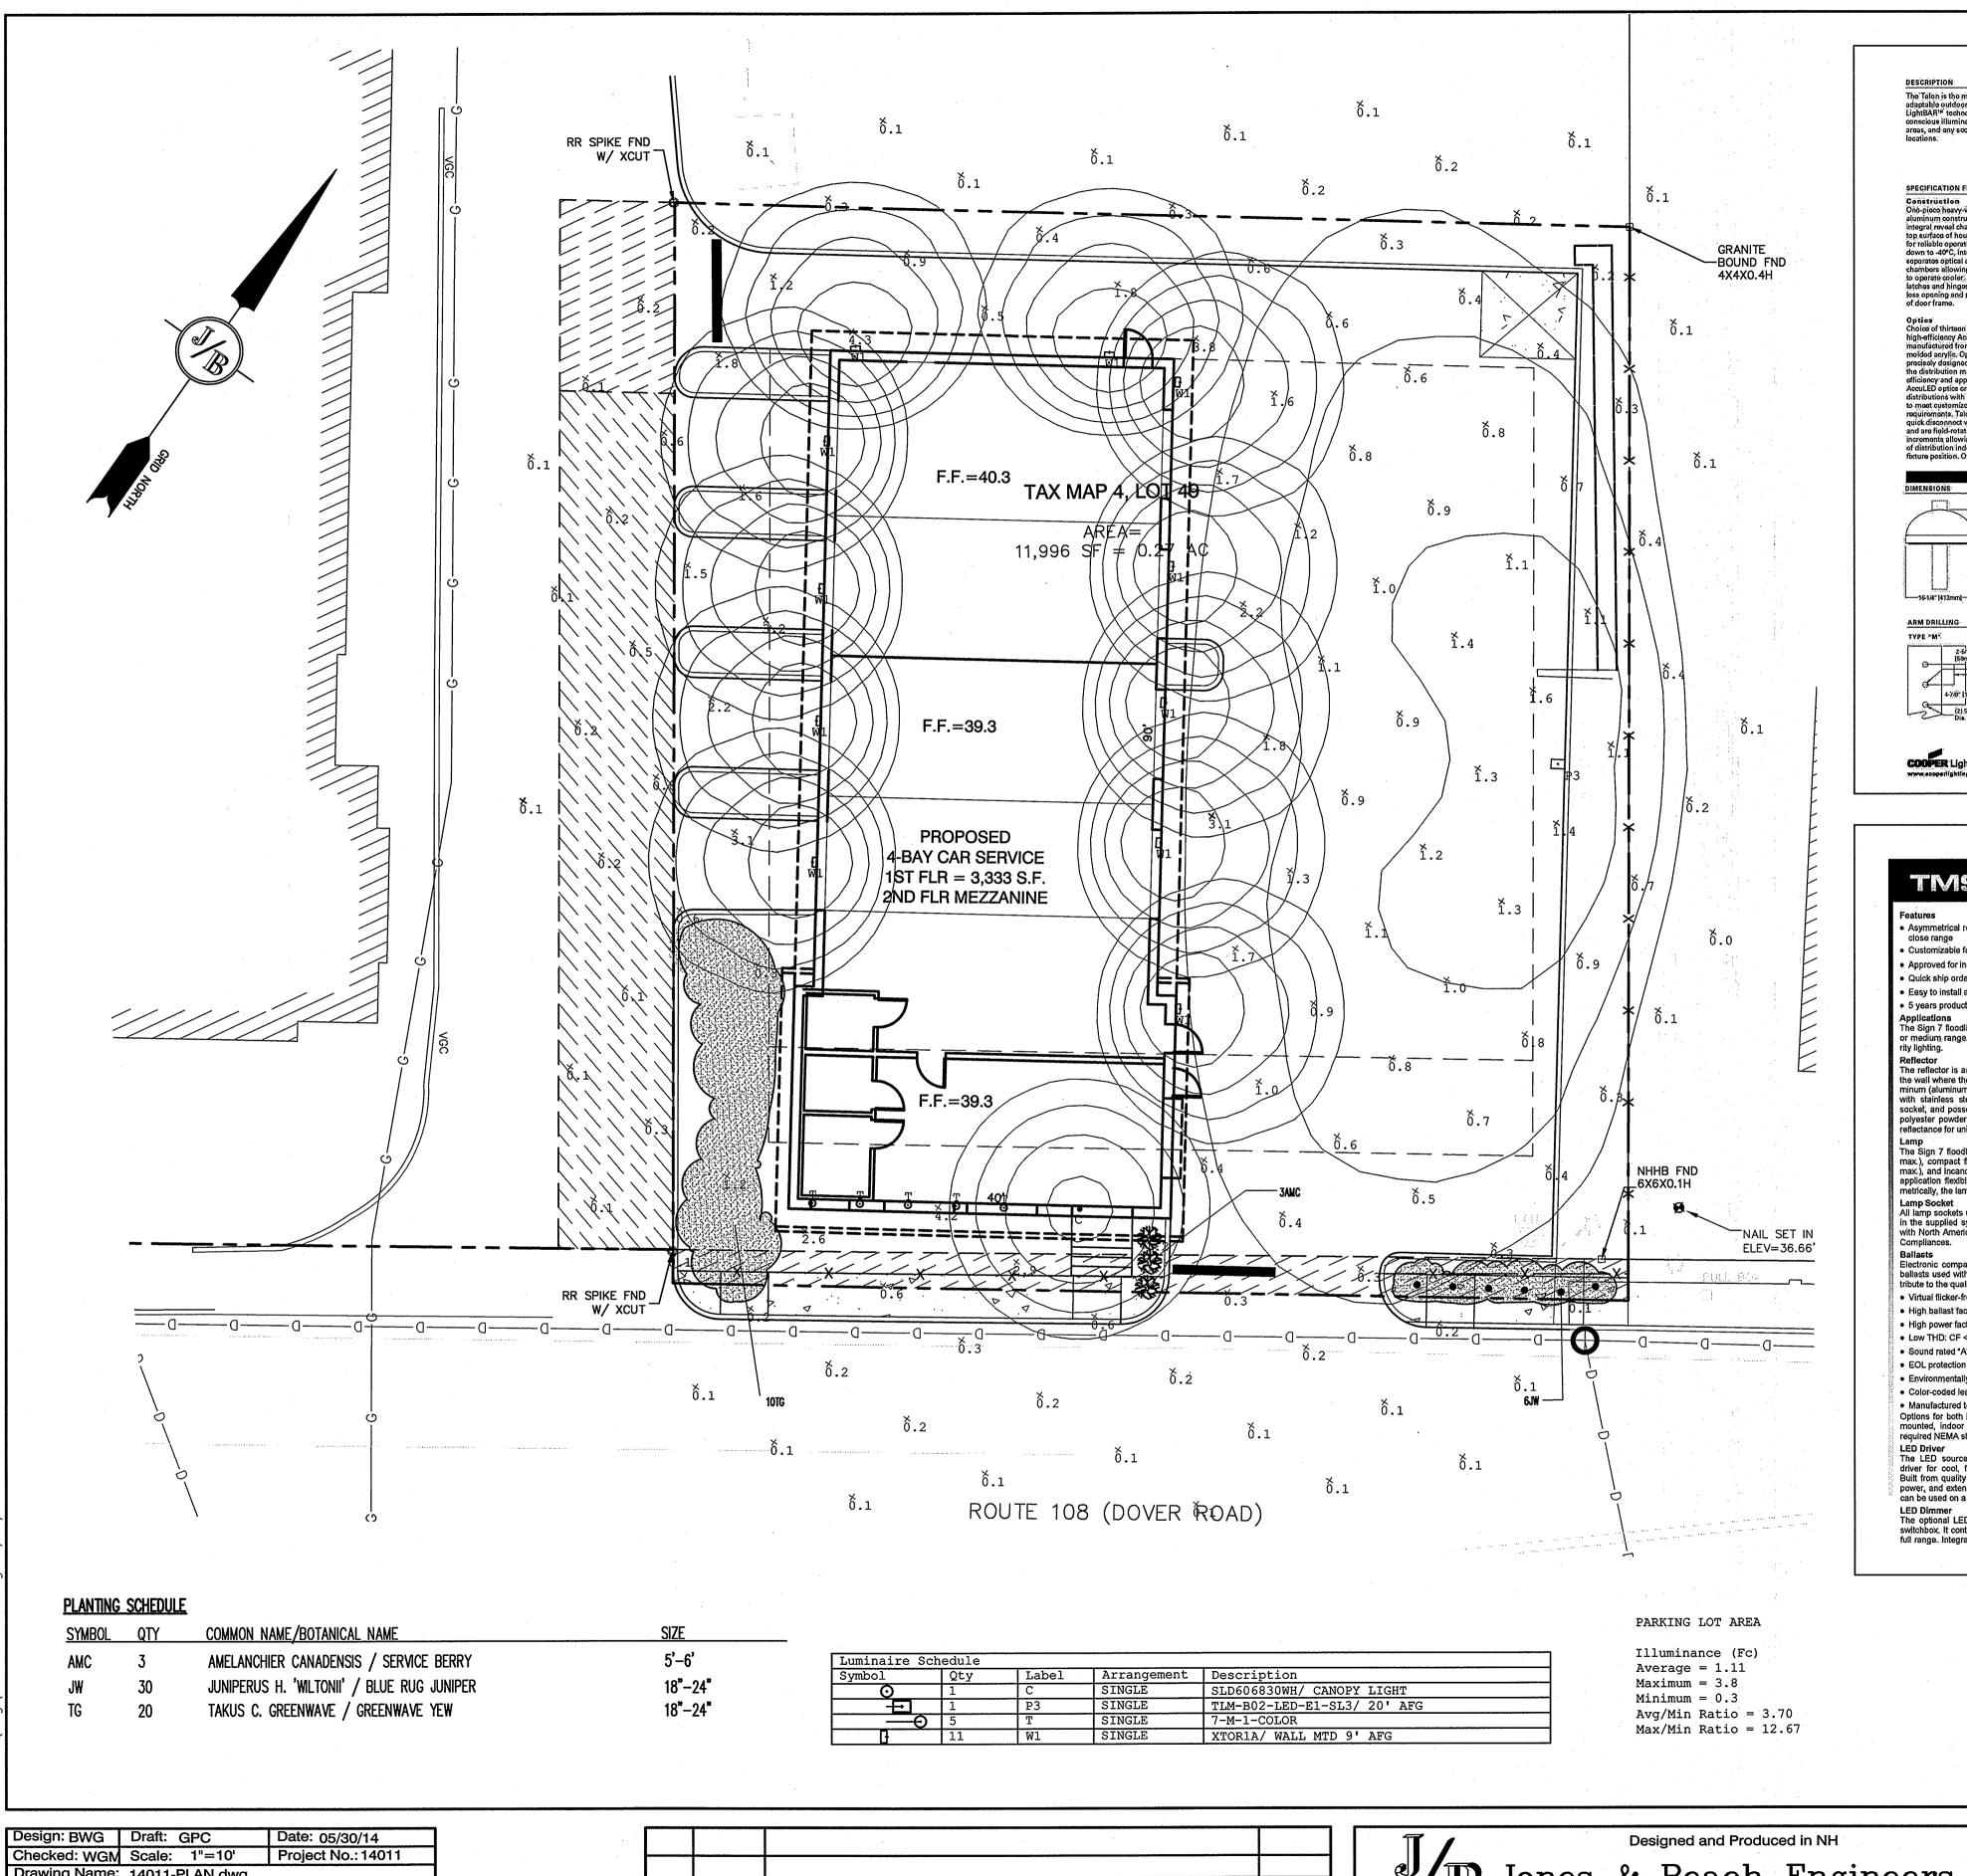

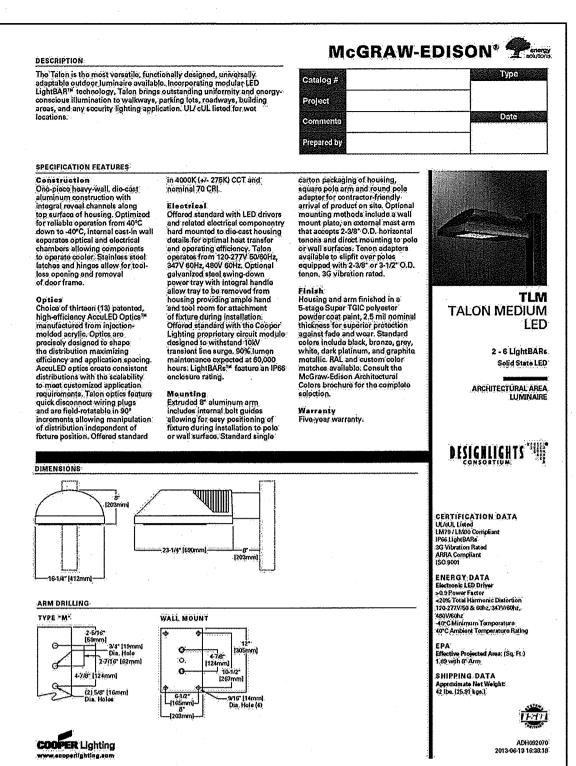


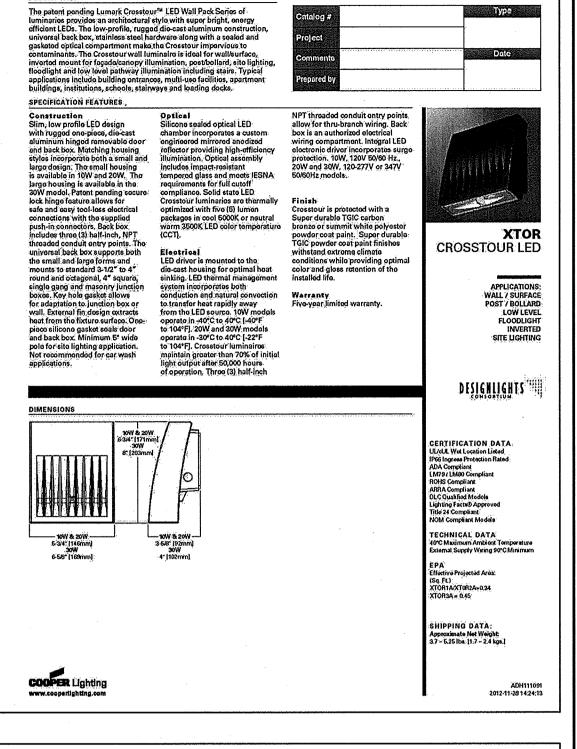

LUMARK®

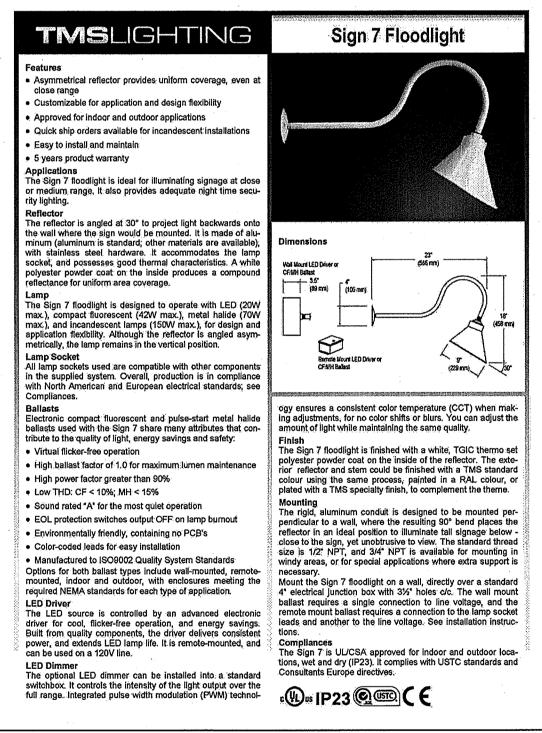




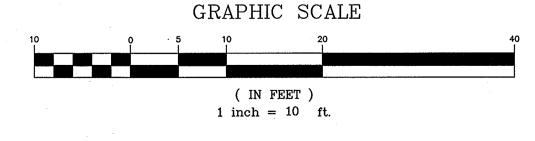

Design: BWG	Draft:	GPC	Date: 05/30/14
			Project No.: 14011
Drawing Name:	14011-	PLAN.dwg	
THIS PLAN SHALL	NOT BE	MODIFIED WITI	HOUT WRITTEN
PERMISSION FRO	M JONES	8 & BEACH ENG	SINEERS, INC. (JBE).
ANY ALTERATION	S, AUTHO	RIZED OR OTH	IERWISE, SHALL BE
AT THE USER'S S	OLE RISK	AND WITHOUT	LIABILITY TO JBE.
	Checked: WGM Drawing Name: THIS PLAN SHALL PERMISSION FRO	Checked: WGM Scale: Drawing Name: 14011- THIS PLAN SHALL NOT BE PERMISSION FROM JONES	Design: BWG Draft: GPC Checked: WGM Scale: 1"=10' Drawing Name: 14011-PLAN.dwg THIS PLAN SHALL NOT BE MODIFIED WITH PERMISSION FROM JONES & BEACH ENCORNY ALTERATIONS, AUTHORIZED OR OTH AT THE USER'S SOLE RISK AND WITHOUT

	T		
·			
0	08/27/14	ISSUED FOR REVIEW	GP
REV.	DATE	REVISION	B

 


85 Portsmouth Ave.	Cinil	Engineering	Sominos	603-772-4746	
PO Box 219	00000	Drug theer they	Dervices	FAX: 603-772-0227	
Stratham, NH 03885			E-MAIL: JBE@JONESANDBEACH.COM		

Plan Name:	LANDSCAPE & LIGHTING PLAN MAP 4, LOT 49
Project:	4-BAY CAR SERVICE 3 DOVER ROAD, ROUTE 108, DURHAM, NH
Applicant:	TROPIC STAR DEVELOPMENT, LLC 321D LAFAYETTE ROAD, HAMPTON, NH 03842

SHEET 6 OF 10 JBE PROJECT NO. 14011

DRAWING No.

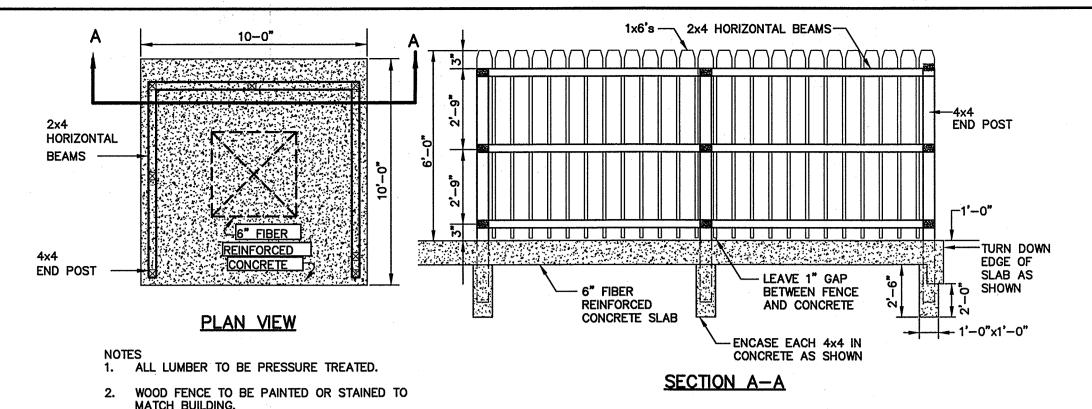

CONC. TURFSTONE PRECAST CONC. PAVERS HAND TIGHT JOINTS SOD CUT TO FILL 3 1/8" VOID - SANDY LOAM TURF MIX 1/2" REVEAL AFTER SETTLE 2" MAX. DEPTH GRANITE CURB--PAVED FINISH SURFACE -BINDER COURSE COMPACT PROCESSED -3000 PSI CONCRETI COMPACT SUBGRADE BASE MATERIAL TO EXTEND 6" FROM EDGE OF TURF BLOCK

TURF BLOCK POROUS PAVERS

NOT TO SCALE

UTILITY NOTES:


NOT TO SCALE

DUMPSTER SCREENING

- PRIOR TO THE START OF CONSTRUCTION, THE CONTRACTOR SHALL COORDINATE WITH THE ENGINEER, ARCHITECT AND/OR OWNER, IN ORDER TO OBTAIN AND/OR PAY ALL THE NECESSARY LOCAL PERMITS, CONNECTION FEES
- 2. THE CONTRACTOR SHALL PROVIDE A MINIMUM NOTICE OF FOURTEEN (14) DAYS TO ALL CORPORATIONS, COMPANIES AND/OR LOCAL AUTHORITIES OWNING OR HAVING A JURISDICTION OVER UTILITIES RUNNING TO, THROUGH OR ACROSS PROJECT AREAS PRIOR TO DEMOLITION AND/OR CONSTRUCTION ACTIVITIES.
- 3. THE LOCATION, SIZE, DEPTH AND SPECIFICATIONS FOR CONSTRUCTION OF PROPOSED PRIVATE UTILITY SERVICES SHALL BE TO THE STANDARDS AND REQUIREMENTS OF THE RESPECTIVE UTILITY COMPANY (ELECTRIC, TELEPHONE, CABLE TELEVISION, FIRE ALARM, GAS, WATER, AND SEWER).
- 4. A PRECONSTRUCTION MEETING SHALL BE HELD WITH THE OWNER, ENGINEER, ARCHITECT, CONTRACTOR, LOCAL OFFICIALS, AND ALL PROJECT—RELATED UTILITY COMPANIES (PUBLIC AND PRIVATE) PRIOR TO START OF
- 5. ALL CONSTRUCTION SHALL CONFORM TO THE TOWN STANDARDS AND REGULATIONS, AND NHDES STANDARDS AND SPECIFICATIONS, WHICHEVER ARE MORE STRINGENT, UNLESS OTHERWISE SPECIFIED.
- ALL CONSTRUCTION ACTIVITIES SHALL CONFORM TO LABOR OCCUPATIONAL SAFETY AND HEALTH ADMINISTRATION (OSHA) RULES AND REGULATIONS.
- 7. BUILDING TO BE SERVICED BY UNDERGROUND UTILITIES UNLESS OTHERWISE NOTED.
- 8. THE CONTRACTOR IS TO VERIFY LOCATION AND DEPTH OF ALL EXISTING UTILITY STUBS PRIOR TO CONSTRUCTION AND DISCONNECT ALL EXISTING SERVICE CONNECTIONS AT THEIR RESPECTIVE MAINS IN ACCORDANCE WITH THE RESPECTIVE UTILITY COMPANY'S STANDARDS AND SPECIFICATIONS. ENGINEER TO BE NOTIFIED.
- 9. AS-BUILT PLANS SHALL BE SUBMITTED TO DEPARTMENT OF PUBLIC WORKS.
- 10. CONTRACTOR TO PROVIDE UNDERDRAIN, AS NECESSARY, AT DISCRETION OF THE PROJECT ENGINEER.
- 11. INVERTS AND SHELVES: MANHOLES SHALL HAVE A BRICK PAVED SHELF AND INVERT, CONSTRUCTED TO CONFORM TO THE SIZE OF PIPE AND FLOW AT CHANGES IN DIRECTION. THE INVERTS SHALL BE LAID OUT IN CURVES OF THE LONGEST RADIUS POSSIBLE TANGENT TO THE CENTER LINE OF THE SEWER PIPES. SHELVES SHALL BE CONSTRUCTED TO THE ELEVATION OF THE THROUGH CHANNEL UNDERLAYMENT OF INVERT, AND SHELF SHALL
- 12. FRAMES AND COVERS: MANHOLE FRAMES AND COVERS SHALL BE OF HEAVY DUTY DESIGN AND PROVIDE A 30 INCH DIA, CLEAR OPENING. THE WORD "SEWER" OR DRAIN" SHALL BE CAST INTO THE CENTER OF THE UPPER FACE OF EACH COVER WITH RAISED, 3" LETTERS.
- 13. SHALLOW MANHOLE: IN LIEU OF A CONE SECTION, WHEN MANHOLE DEPTH IS LESS THAN 6 FEET, A REINFORCED CONCRETE SLAB COVER MAY BE USED HAVING AN ECCENTRIC ENTRANCE OPENING AND CAPABLE OF
- 14. CONTRACTOR SHALL PLACE 2" WIDE METAL WIRE IMPREGNATED RED PLASTIC WARNING TAPE OVER ENTIRE LENGTH OF ALL GRAVITY SEWERS, SERVICES, AND FORCE MAINS.
- 15. SANITARY SEWER FLOW CALCULATIONS:
 - 8 EMPLOYEES @ 35 GPD/EMPLOYEES TOTAL FLOW = 630 GPD
- 16. PROPOSED RIM ELEVATIONS OF DRAINAGE AND SANITARY MANHOLES ARE APPROXIMATE. FINAL ELEVATIONS ARE TO BE SET FLUSH WITH FINISH GRADES. ADJUST ALL OTHER RIM ELEVATIONS OF MANHOLES, WATER GATES, GAS GATES AND OTHER UTILITIES TO FINISH GRADE AS SHOWN ON THE GRADING AND DRAINAGE PLAN.
- 17. ALL WATER MAINS AND SERVICE PIPES SHALL HAVE A MINIMUM 12" VERTICAL AND 24" HORIZONTAL SEPARATION TO MANHOLES, OR CONTRACTOR SHALL INSTALL BOARD INSULATION FOR FREEZING PROTECTION.
- 18. WATER MAINS SHALL BE HYDROSTATICALLY PRESSURE TESTED FOR LEAKAGE PRIOR TO ACCEPTANCE. WATERMAINS SHALL BE TESTED AT 1.5 TIMES THE WORKING PRESSURE OR 150 PSI, WHICH EVER IS GREATER. TESTING SHALL BE CONDUCTED IN ACCORDANCE WITH SECTION 4 OF AWWA STANDARD C 600. WATERMAINS SHALL BE DISINFECTED AFTER THE ACCEPTANCE OF THE PRESSURE AND LEAKAGE TESTS ACCORDING TO AWWA STANDARD
- 19. ALL WATER AND SANITARY LEADS TO BUILDING(S) SHALL END 5' OUTSIDE THE BUILDING LIMITS AS SHOWN ON PLANS AND SHALL BE PROVIDED WITH A TEMPORARY PLUG AND WITNESS AT END.
- 20. IF THE BUILDING IS REQUIRED TO HAVE A SPRINKLER SYSTEM, A PRECONSTRUCTION MEETING SHALL BE HELD BETWEEN THE CONTRACTOR, OWNER, ARCHITECT AND THE LOCAL FIRE DEPARTMENT PRIOR TO THE INSTALLATION.
- 21. THRUST BLOCKS SHALL BE PROVIDED AT ALL BENDS, TEES, MECHANICAL JOINTS AND FIRE HYDRANTS.
- 22. DIMENSIONS ARE SHOWN TO CENTERLINE OF PIPE OR FITTING.
- 23. REFER TO FIRE PROTECTION SHEETS FOR LOCATION AND DETAIL OF FIRE LINE LEAD IN TO BUILDING.
- 24. FIRE LINE SHALL BE STUBBED UP 1' ABOVE FINISH FLOOR ELEVATION IN SPRINKLER ROOM.
- 25. AN APPROVED AUTOMATIC SPRINKLER SYSTEM SHALL BE INSTALLED IN ACCORDANCE WITH 101 LIFE SAFETY CODE/NFPA 1 AND LOCAL REGULATIONS. FIRE DEPARTMENT CONNECTION SHALL BE FIELD VERIFIED BY LOCAL FIRE DEPARTMENT TO ENSURE OPTIMUM PLACEMENT.
- 26. THE CONTRACTOR SHALL HAVE THE APPROVAL OF ALL GOVERNING AGENCIES HAVING JURISDICTION OVER FIRE PROTECTION SYSTEM PRIOR TO INSTALLATION.
- 27. CONTRACTOR TO FURNISH SHOP DRAWINGS FOR UTILITY RELATED ITEMS TO ENSURE CONFORMANCE WITH THE PLANS AND SPECIFICATIONS. SHOP DRAWINGS SHOULD BE SENT IN TRIPLICATE TO THE DESIGN ENGINEER FOR REVIEW AND APPROVAL PRIOR TO INSTALLATION.
- 28. EXISTING UTILITIES SHALL BE DIGSAFED BEFORE CONSTRUCTION.
- 29. ALL WATER LINES SHOULD HAVE TESTABLE BACKFLOW PREVENTERS AT THE ENTRANCE TO EACH BUILDING.
- 30. ENV-WQ 704.07 GRAVITY SEWER PIPE TESTING: GRAVITY SEWERS SHALL BE TESTED FOR WATER TIGHTNESS BY USE OF LOW-PRESSURE AIR TESTS CONFORMING WITH ASTM F1417-92(2005) OR UNI-BELL PVC PIPE ASSOCIATION UNI-B-6. LINES SHALL BE CLEANED AND VISUALLY INSPECTED AND TRUE TO LINE AND GRADE. DEFLECTION TESTS SHALL TAKE PLACE AFTER 30 DAYS FOLLOWING INSTALLATION AND THE MAXIMUM ALLOWABLE DEFLECTION OF FLEXIBLE SEWER PIPE SHALL BE 7 1/2% OF AVERAGE INSIDE DIAMETER.
- 31. SANITARY SEWER LINES SHALL BE LOCATED AT LEAST TEN (10) FEET HORIZONTALLY FROM AN EXISTING OR PROPOSED WATER LINE. WHEN A SEWER LINE CROSSES UNDER A WATER LINE, THE SEWER PIPE JOINTS SHALL BE LOCATED AT LEAST 6 FEET HORIZONTALLY FROM THE WATERMAIN. THE SEWER LINE SHALL ALSO MAINTAIN A VERTICAL SEPARATION OF NOT LESS THAN 18 INCHES.
- 32. SEWERS SHALL BE BURIED TO A MINIMUM DEPTH OF 6 FEET BELOW GRADE IN ALL ROADWAY LOCATIONS, AND TO A MINIMUM DEPTH OF 4 FEET BELOW GRADE IN ALL CROSS-COUNTRY LOCATIONS. PROVIDE TWO-INCHES OF R-10 FOAM BOARD INSULATION 2-FOOT WIDE TO BE INSTALLED 6-INCHES OVER SEWER PIPE IN AREAS WHERE DEPTH IS NOT ACHIEVED. A WAIVER FROM THE DEPARTMENT OF ENVIRONMENTAL SERVICES WASTEWATER ENGINEERING BUREAU IS REQUIRED PRIOR TO INSTALLING SEWER AT LESS THAN MINIMUM COVER.
- 33. SEWER AND WATER INFRASTRUCTURE ON PRIVATE PROPERTY IS TO REMAIN PRIVATE, HOWEVER, THE TOWN RESERVES THE RIGHT TO ENTER THE PROPERTY IN ORDER TO INSPECT, REPAIR AND/OR TERMINATE INDIVIDUAL SEWER OR WATER SERVICES (AT OWNER'S EXPENSE). THIS RIGHT IS TO BE CONVEYED TO THE TOWN IN THE SITE'S DECLARATION OF CONDOMINIUM DOCUMENTS, AND IN ALL INDIVIDUAL DEEDS.
- 34. ALL WATER AND SANITARY LEADS TO BUILDING(S) SHALL END AT RIGHT OF WAY AS SHOWN ON PLANS AND SHALL BE PROVIDED WITH A TEMPORARY PLUG AND WITNESS AT END.
- 35. THE CONTRACTOR SHALL MAINTAIN WATER SERVICE TO USERS AT ALL TIMES. REQUIREMENTS BY THE TOWN WATER DEPARTMENT REGARDING NOTIFICATION FOR INTERRUPTION OF SERVICE SHOULD BE INCLUDED (TYPICALLY 24 HOURS) AND ALLOWABLE INTERRUPTION DURATION. WATER TESTING AND DISINFECTION REQUIREMENTS SHALL BE PERFORMED IN ACCORDANCE WITH TOWN AND NHDES REGULATIONS.
- 36. ALL TRENCHING, PIPE LAYING, AND BACKFILLING SHALL BE IN ACCORDANCE WITH FEDERAL OSHA REGULATIONS.

SLOPED GRANITE CURB

NOT TO SCALE

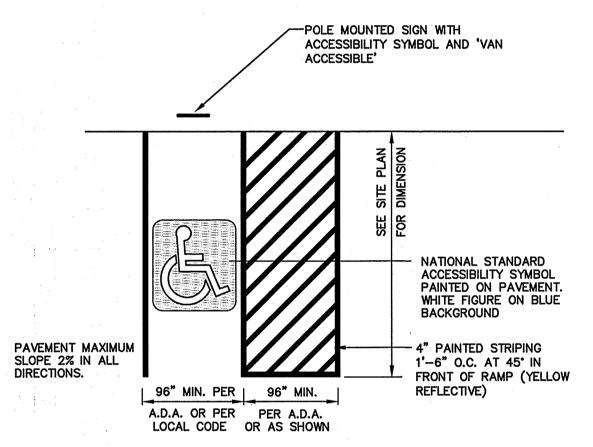


1. CURB TO BE PLACED PRIOR TO PLACING TOP SURFACE COURSE.

2. JOINTS BETWEEN STONES SHALL BE MORTARED.

HANDICAP PARKING LAYOUT

NOT TO SCALE

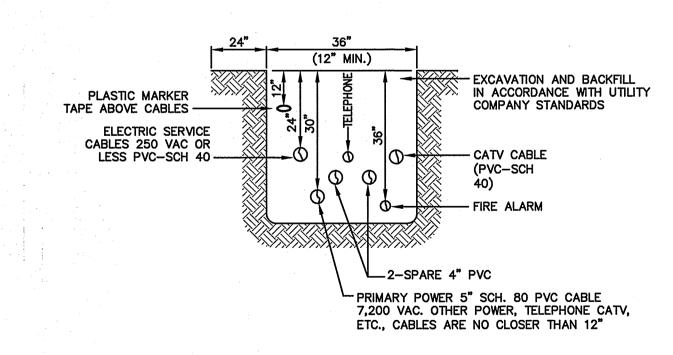

NOTE: ALL UTILITIES SHALL BE REVIEWED AND APPROVED BY APPROPRIATE UTILITY COMPANY.

UTILITY TRENCH

NOT TO SCALE

- 3/4"x8' GROUND ROD **COMPACTED OR** CONNECT TO INSIDE UNDISTURBED METAL POLE SUBGRADE --CADWELD 2'-6"

POLE FOUNDATION

ANCHOR BOLTS FURNISHED BY

-1" CHAMFER AROUND BASE

(TREATMENT VARIES)

CONTRACTOR

CONDUITS BY ELECTRICAL

#3 TIES @ 12" C.C.

TOP TO BOTTOM - FINISH GRADE


THE ELECTRICAL CONTRACTOR &

INSTALLED BY GENERAL CONTRACTOR

LIGHT POLE BASES IN PARKING LOT TO BE PAINTED TO MATCH POLES

PARKING LOT LIGHT BASE

6-#5 BARS

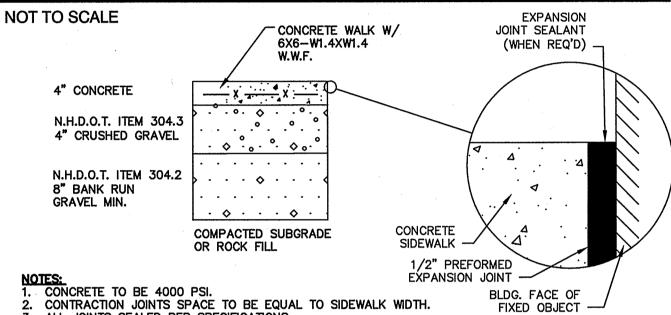


ALL JOINTS SEALED PER SPECIFICATIONS. 4. PROVIDE A 1/2" NON-EXTRUDING EXPANSION JOINT AGAINST STRUCTURE AND EVERY 16' ALONG SIDEWALK.

CONCRETE SIDEWALK

NOT TO SCALE -1" - 3/8" HOT BIT. PAVEMENT WEARING COURSE 2" - 3/4" HOT BIT. PAVEMENT 6" - NHDOT ITEM 304.3 CRUSHED GRAVEL 95% MIN. COMPACTION INCLUDING RECLAIMED MATERIAL 12" - NHDOT ITEM 304.2 BANK RUN GRAVEL (MIN) 95% MIN. COMPACTION

95% COMPACTED SUBGRADE OR ROCK FILL

TYPICAL BITUMINOUS PAVEMENT

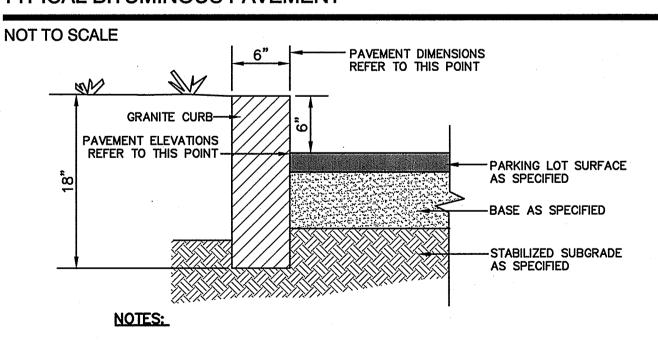


1. JOINTS BETWEEN STONES SHALL BE MORTARED.

2. EDGING TO BE PLACED PRIOR TO PLACING TOP SURFACE COURSE. 6" VERTICAL GRANITE CURB


NOT TO SCALE

Design: BWG Draft: GPC Date: 05/30/14 Checked: WGM Scale: AS NOTED Project No.: 14011 Drawing Name: 14011-PLAN.dwg

THIS PLAN SHALL NOT BE MODIFIED WITHOUT WRITTEN PERMISSION FROM JONES & BEACH ENGINEERS, INC. (JBE). ANY ALTERATIONS, AUTHORIZED OR OTHERWISE, SHALL BE AT THE USER'S SOLE RISK AND WITHOUT LIABILITY TO JBE.

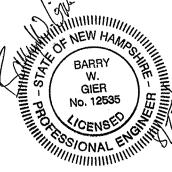


		•	
0	08/27/14	ISSUED FOR REVIEW	GPC
REV.	DATE	REVISION	BY

 

85 Portsmouth Ave. Civil Engineering Services 603-772-4746 FAX: 603-772-0227 PO Box 219 E-MAIL: JBE@JONESANDBEACH.COM Stratham, NH 03885

DETAIL SHEET Plan Name: 4-BAY CAR SERVICE 3 DOVER ROAD, ROUTE 108, DURHAM, NH Project: TROPIC STAR DEVELOPMENT, LLC Applicant: 321D LAFAYETTE ROAD, HAMPTON, NH 03842

DRAWING No. SHEET 7 OF 10 JBE PROJECT NO. 14011

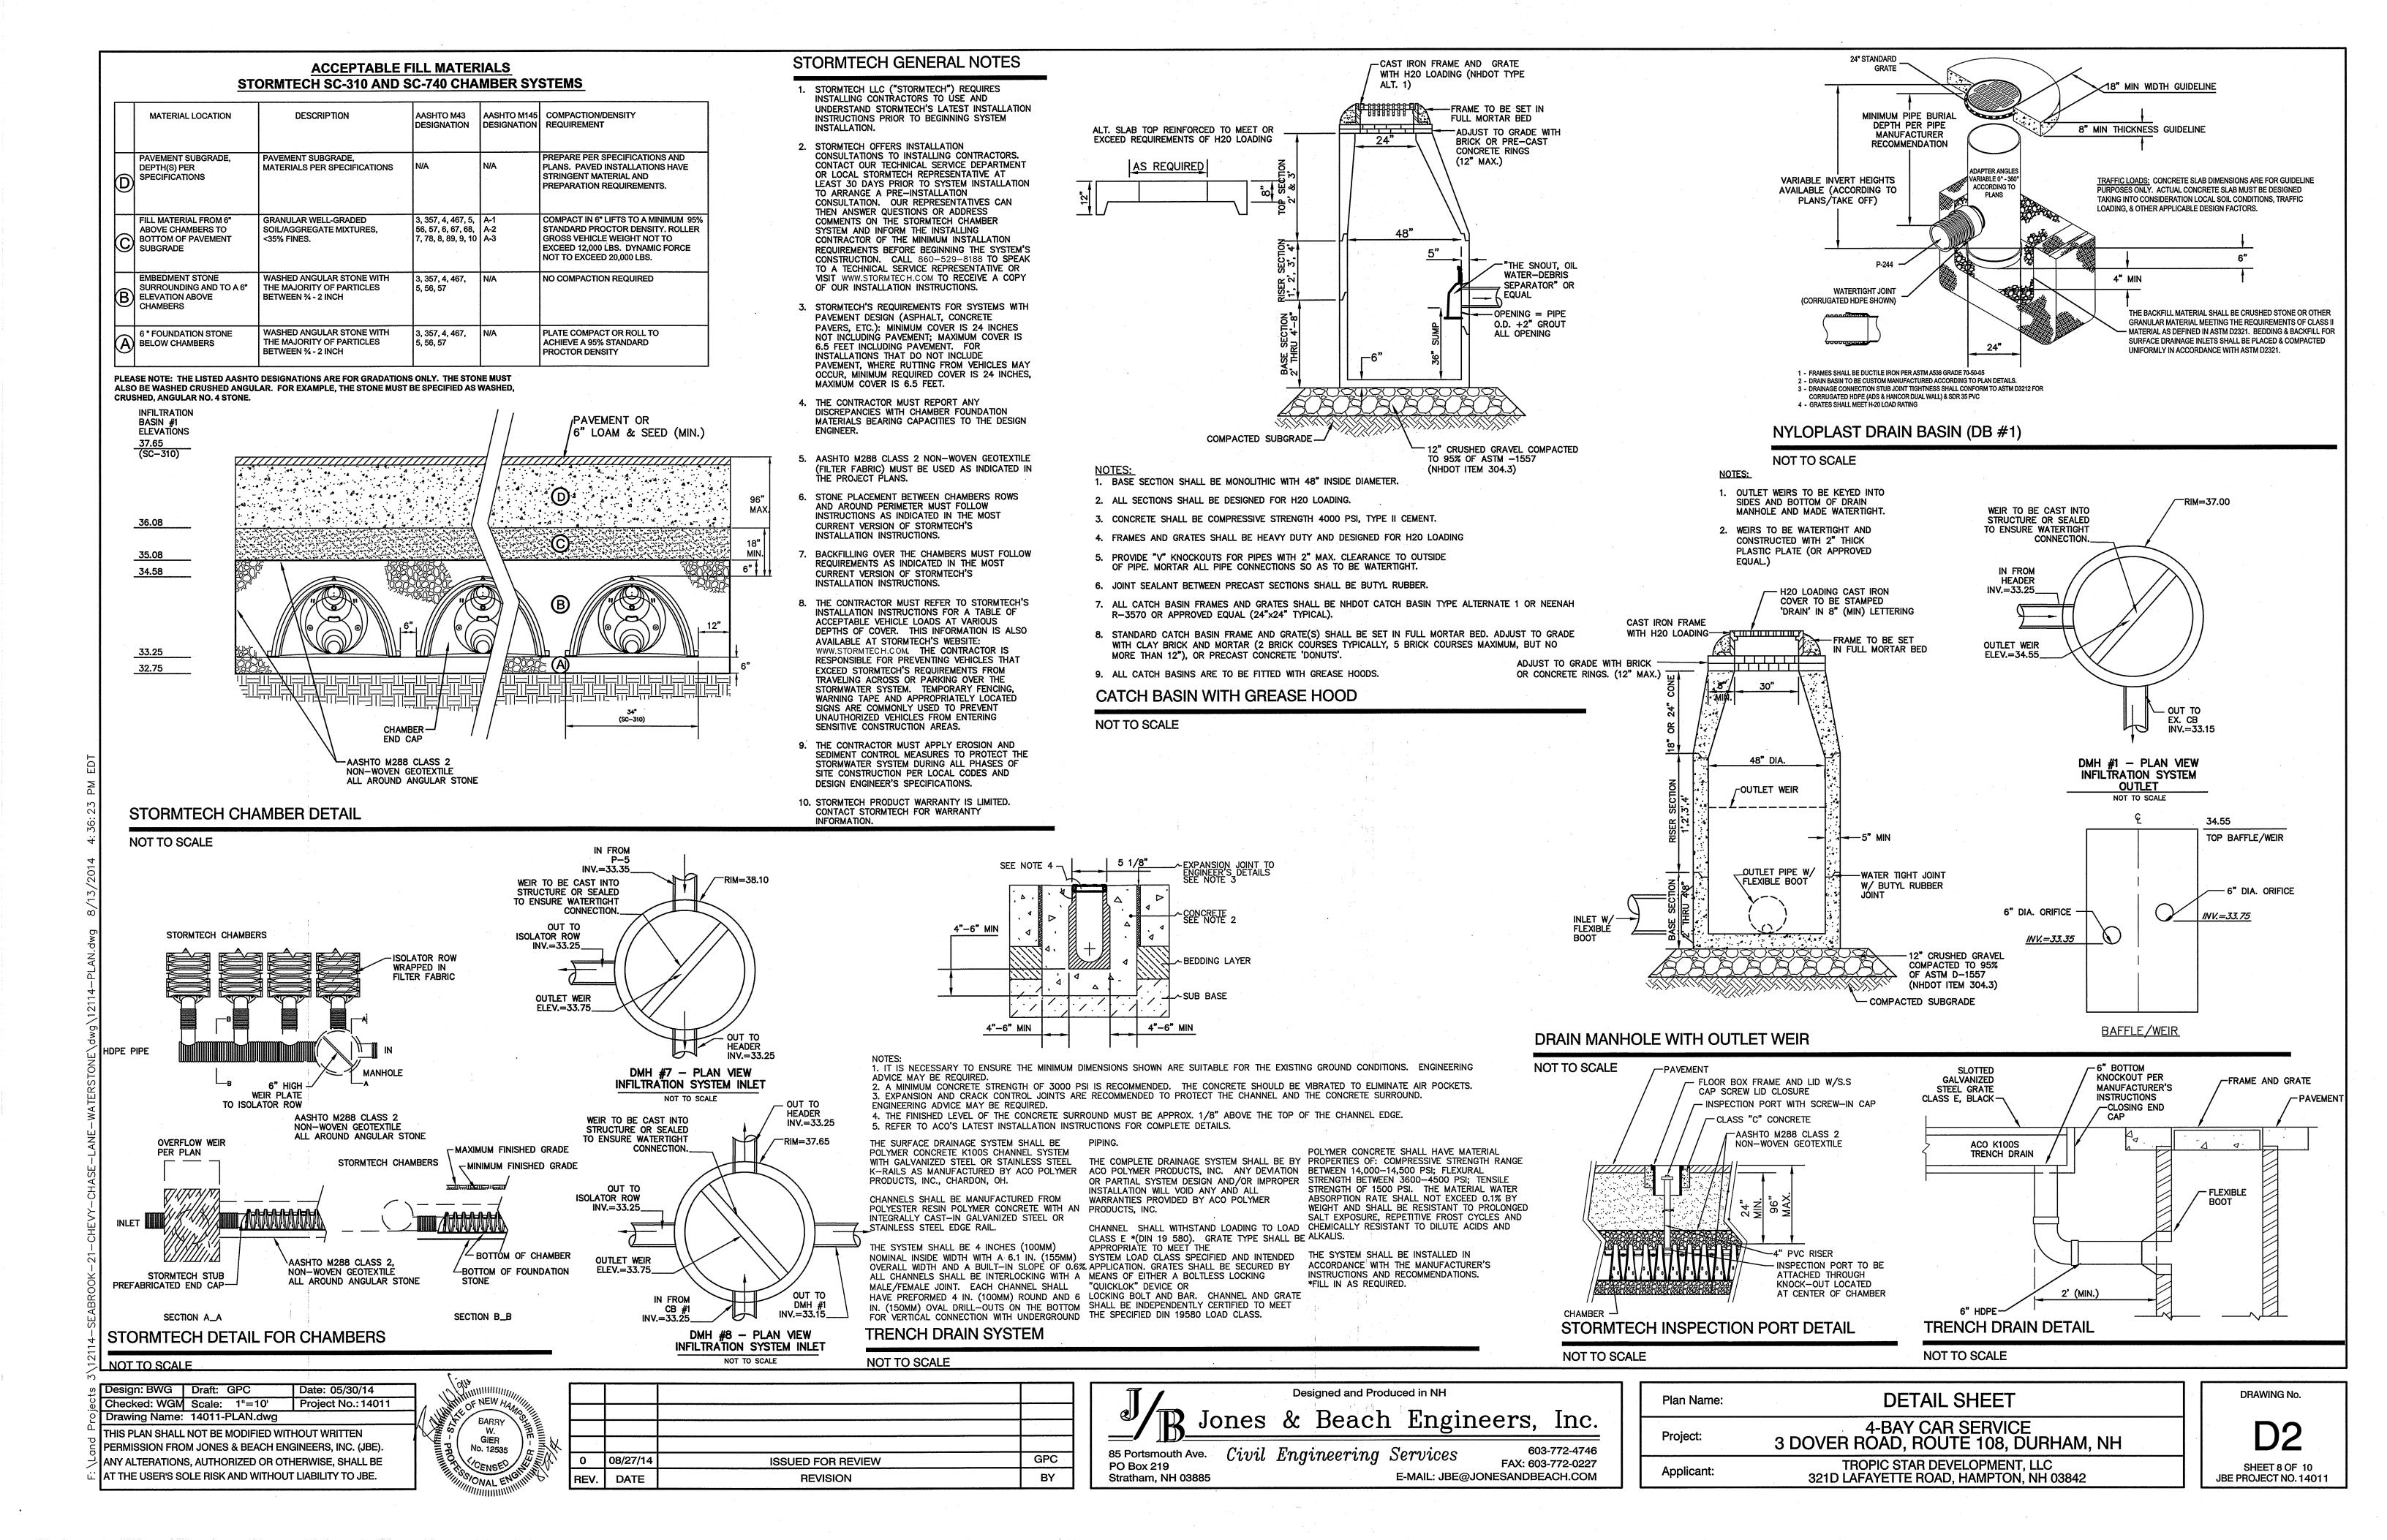


MAINTENANCE NOTE:

1. ALL STRUCTURES SHOULD BE INSPECTED AFTER EVERY RAINFALL AND REPAIRS MADE AS NECESSARY. SEDIMENT SHOULD BE REMOVED FROM TRAPPING DEVICES AFTER THE SEDIMENT HAS REACHED A MAXIMUM OF ONE HALF THE DEPTH OF THE TRAP. THE SEDIMENT SHOULD BE DISPOSED IN A SUITABLE UPLAND AREA AND PROTECTED FROM EROSION BY EITHER STRUCTURE OR VEGETATIVE MEANS. THE TEMPORARY TRAPS SHOULD BE REMOVED AND THE AREA REPAIRED AS SOON AS THE CONTRIBUTING DRAINAGE AREA TO THE INLET HAS BEEN COMPLETELY STABILIZED.

TEMPORARY CATCH BASIN INLET PROTECTION (Block and Gravel Drop Inlet Sediment Filter)

NOT TO SCALE

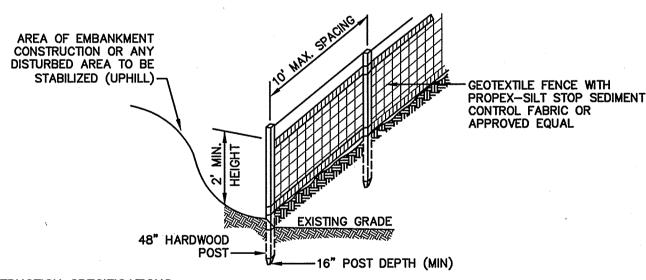

CONSTRUCTION SPECIFICATIONS:


- . WOVEN FABRIC FENCE TO BE FASTENED SECURELY TO FENCE POSTS WITH WIRE TIES OR STAPLES. FILTER CLOTH SHALL BE FASTENED TO WOVEN WIRE EVERY 24" AT TOP, MID AND BOTTOM AND EMBEDDED IN THE GROUND A MINIMUM OF 8" AND THEN COVERED WITH SOIL.
- . THE FENCE POSTS SHALL BE A MINIMUM OF 48" LONG, SPACED A MAXIMUM 10' APART, AND DRIVEN A MINIMUM OF 16" INTO THE GROUND.
- 3. WHEN TWO SECTIONS OF FILTER CLOTH ADJOIN EACH OTHER, THE ENDS OF THE FABRIC SHALL BE OVERLAPPED 6", FOLDED AND STAPLED TO PREVENT SEDIMENT FROM BY-PASSING.
- I. MAINTENANCE SHALL BE PERFORMED AS NEEDED AND SEDIMENT REMOVED AND PROPERLY DISPOSED OF WHEN IT IS 6" DEEP OR VISIBLE 'BULGES' DEVELOP IN THE SILT FENCE.
- 5. PLACE THE ENDS OF THE SILT FENCE UP CONTOUR TO PROVIDE FOR SEDIMENT STORAGE.
- SILT FENCE SHALL REMAIN IN PLACE FOR 24 MONTHS.


SILT FENCE

Design: BWG | Draft: GPC

Drawing Name: 14011-PLAN.dwg

NOT TO SCALE

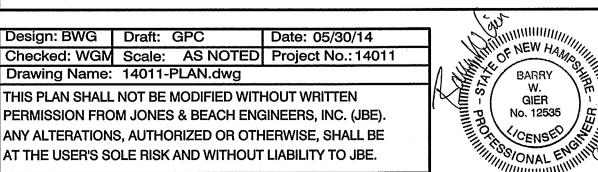

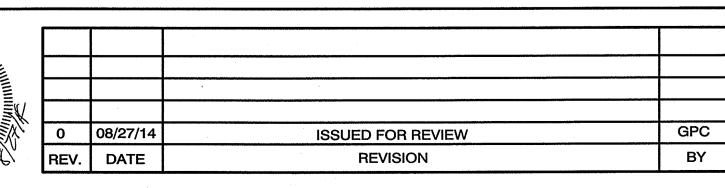

-MAXIMUM RECOMMENDED UNCONTROLLED SLOPE LENGTH ~ DISTURBED AREA (UPHILL) -CONTOUR LINES___ 600' RECOMMENDED MAXIMUM FENCING IS TO RUN WITH THE CONTOURS ACROSS A SLOPE

STORAGE AREA

7. SILT FENCES SHALL BE REMOVED WHEN NO LONGER NEEDED AND THE SEDIMENT COLLECTED SHALL BE DISPOSED AS DIRECTED BY THE ENGINEER. THE AREA DISTURBED BY THE REMOVAL SHALL BE SMOOTHED AND REVEGETATED.

-FLARE ENDS UPHILL TO PROVIDE

TRAPPING CAPABILITY AND SEDIMENT

MAINTENANCE:

- 1. SILT FENCES SHALL BE INSPECTED IMMEDIATELY AFTER EACH RAINFALL AND AT LEAST DAILY DURING PROLONGED RAINFALL. ANY REPAIRS THAT ARE REQUIRED SHALL BE DONE IMMEDIATELY.
- 2. IF THE FABRIC ON A SILT FENCE SHOULD DECOMPOSE OR BECOME INEFFECTIVE DURING THE EXPECTED LIFE OF THE FENCE, THE FABRIC SHALL BE REPLACED PROMPTLY.
- 3. SEDIMENT DEPOSITS SHOULD BE INSPECTED AFTER EVERY STORM EVENT. THE DEPOSITS SHOULD BE REMOVED WHEN THEY REACH APPROXIMATELY ONE HALF THE HEIGHT OF THE BARRIER.
- 4. SEDIMENT DEPOSITS THAT ARE REMOVED, OR LEFT IN PLACE AFTER THE FABRIC HAS BEEN REMOVED, SHALL BE GRADED TO CONFORM WITH THE EXISTING TOPOGRAPHY AND VEGETATED.

SEEDING SPECIFICATIONS

- 1. GRADING AND SHAPING A. SLOPES SHALL NOT BE STEEPER THAN 2:1 WITHOUT APPROPRIATE EROSION CONTROL MEASURES AS
- SPECIFIED ON THE PLANS (3:1 SLOPES OR FLATTER ARE PREFERRED). B. WHERE MOWING WILL BE DONE, 3:1 SLOPES OR FLATTER ARE RECOMMENDED.

2. SEEDBED PREPARATION

- A. SURFACE AND SEEPAGE WATER SHOULD BE DRAINED OR DIVERTED FROM THE SITE TO PREVENT DROWNING
- OR WINTER KILLING OF THE PLANTS. B. STONES LARGER THAN 4 INCHES AND TRASH SHOULD BE REMOVED BECAUSE THEY INTERFERE WITH SEEDING AND FUTURE MAINTENANCE OF THE AREA. WHERE FEASIBLE, THE SOIL SHOULD BE TILLED TO A DEPTH OF ABOUT 4 INCHES TO PREPARE A SEEDBED AND FERTILIZER AND LIME MIXED INTO THE SOIL. THE SEEDBED SHOULD BE LEFT IN A REASONABLY FIRM AND SMOOTH CONDITION. THE LAST TILLAGE OPERATION SHOULD BE PERFORMED ACROSS THE SLOPE WHEREVER PRACTICAL.

3. ESTABLISHING A STAND

- A. LIME AND FERTILIZER SHOULD BE APPLIED PRIOR TO OR AT THE TIME OF SEEDING AND INCORPORATED INTO THE SOIL. TYPES AND AMOUNTS OF LIME AND FERTILIZER SHOULD BE BASED ON AN EVALUATION OF SOIL TESTS. WHEN A SOIL TEST IS NOT AVAILABLE, THE FOLLOWING MINIMUM AMOUNTS SHOULD BE
- AGRICULTURAL LIMESTONE, 2 TONS PER ACRE OR 100 LBS. PER 1,000 SQ.FT.
- NITROGEN(N), 50 LBS. PER ACRE OR 1.1 LBS. PER 1,000 SQ.FT.
- PHOSPHATE(P205), 100 LBS. PER ACRE OR 2.2 LBS. PER 1,000 SQ.FT. POTASH(K2O), 100 LBS. PER ACRE OR 2.2 LBS. PER 1,000 SQ.FT.
- (NOTE: THIS IS THE EQUIVALENT OF 500 LBS. PER ACRE OF 10-20-20 FERTILIZER OR 1,000 LBS. PER ACRE OF 5-10-10.)
- B. SEED SHOULD BE SPREAD UNIFORMLY BY THE METHOD MOST APPROPRIATE FOR THE SITE, METHODS INCLUDE BROADCASTING, DRILLING AND HYDROSEEDING, WHERE BROADCASTING IS USED, COVER SEED WITH .25 INCH OF SOIL OR LESS, BY CULTIPACKING OR RAKING.
- C. REFER TO THE 'SEEDING GUIDE' AND 'SEEDING RATES' TABLES ON THIS SHEET FOR APPROPRIATE SEED MIXTURES AND RATES OF SEEDING. ALL LEGUMES (CROWNVETCH, BIRDSFOOT, TREFOIL AND FLATPEA) MUST BE INOCULATED WITH THEIR SPECIFIC INOCULANT PRIOR TO THEIR INTRODUCTION TO THE SITE.
- D. WHEN SEEDED AREAS ARE MULCHED, PLANTINGS MAY BE MADE FROM EARLY SPRING TO EARLY OCTOBER. WHEN SEEDED AREAS ARE NOT MULCHED, PLANTINGS SHOULD BE MADE FROM EARLY SPRING TO MAY 20th OR FROM AUGUST 10th TO SEPTEMBER 1st.

YET COMPLETE.

85 Portsmouth Ave.

Stratham, NH 03885

PO Box 219

A. HAY, STRAW, OR OTHER MULCH, WHEN NEEDED, SHOULD BE APPLIED IMMEDIATELY AFTER SEEDING. B. MULCH WILL BE HELD IN PLACE USING APPROPRIATE TECHNIQUES FROM THE BEST MANAGEMENT PRACTICE FOR MULCHING. HAY OR STRAW MULCH SHALL BE PLACED AT A RATE OF 90 LBS PER 1000 S.F.

5. MAINTENANCE TO ESTABLISH A STAND

- A. PLANTED AREAS SHOULD BE PROTECTED FROM DAMAGE BY FIRE, GRAZING, TRAFFIC, AND DENSE WEED
- B. FERTILIZATION NEEDS SHOULD BE DETERMINED BY ONSITE INSPECTIONS. SUPPLEMENTAL FERTILIZER IS USUALLY THE KEY TO FULLY COMPLETE THE ESTABLISHMENT OF THE STAND BECAUSE MOST PERENNIALS TAKE 2 TO 3 YEARS TO BECOME FULLY ESTABLISHED.
- C. IN WATERWAYS, CHANNELS, OR SWALES WHERE UNIFORM FLOW CONDITIONS ARE ANTICIPATED, ANNUAL MOWING MAY BE NECESSARY TO CONTROL GROWTH OF WOODY VEGETATION.

USE	SEEDING MIXTURE 1/	DROUGHTY	WELL DRAINED	MODERATELY WELL DRAINED	POORLY DRAINED
STEEP CUTS AND FILLS, BORROW AND DISPOSAL AREAS	A B C	FAIR POOR POOR	GOOD GOOD	GOOD FAIR EXCELLENT	FAIR FAIR GOOD
AREAS	D	FAIR	EXCELLENT	EXCELLENT	POOR
WATERWAYS, EMERGENC' SPILLWAYS, AND OTHER CHANNELS WITH FLOWING WATER.		GOOD GOOD	GOOD EXCELLENT	GOOD EXCELLENT	FAIR FAIR
LIGHTLY USED PARKING LOTS, ODD AREAS, UNUSED LANDS, AND LOW INTENSITY USE RECREATION SITES.	A B C	GOOD GOOD GOOD	GOOD GOOD EXCELLENT	GOOD FAIR EXCELLENT	FAIR POOR FAIR
PLAY AREAS AND ATHLETIC FIELDS. (TOPSOIL IS ESSENTIAL FOR GOOD TURF.)	E // 1	FAIR FAIR	EXCELLENT EXCELLENT	EXCELLENT EXCELLENT	<u>2/</u> 2/
00 AVEL DIT OFF AUL DI	4 04 IN ADDEND	V COD DECOM	ACNO ATION DEGADE	NINO DEOLAMATIO	N 05 CAND

GRAVEL PIT, SEE NH-PM-24 IN APPENDIX FOR RECOMMENDATION REGARDING RECLAMATION OF

/ REFER TO SEEDING MIXTURES AND RATES IN TABLE BELOW.

2/ POORLY DRAINED SOILS ARE NOT DESIRABLE FOR USE AS PLAYING AREA AND ATHLETIC FIELDS. NOTE: TEMPORARY SEED MIX FOR STABILIZATION OF TURF SHALL BE WINTER RYE OR OATS AT A RATE OF 2.5 LBS. PER 1000 S.F. AND SHALL BE PLACED PRIOR TO OCTOBER 15th, IF PERMANENT SEEDING NOT

SEEDING GUIDE

		a adibl	
	MIXTURE	POUNDS PER ACRE	POUNDS PER 1.000 Sq. Ft
	A. TALL FESCUE CREEPING RED FESCUE RED TOP TOTAL	20 20 <u>2</u> 42	0.45 0.45 <u>0.05</u> 0.95
	B. TALL FESCUE CREEPING RED FESCUE CROWN VETCH OR	15 10 15	0.35 0.25 0.35
	FLAT PEA TOTAL	30 40 OR 55	0.75 0.95 OR 1.35
*	C. TALL FESCUE CREEPING RED FESCUE BIRDS FOOT TREFOIL TOTAL	20 20 <u>8</u> 48	0.45 0.45 <u>0.20</u> 1.10
	D. TALL FESCUE FLAT PEA TOTAL	20 30 50	0.45 <u>0.75</u> 1.20
,	E. CREEPING RED FESCUE 1/ KENTUCKY BLUEGRASS 1/ TOTAL	50 50 100	1.15 1.15 2.30
	F. TALL FESCUE 1	150	3.60
	1/ FOR HEAVY USE ATHLETIC FIELDS NEW HAMPSHIRE COOPERATIVE EXTENCURRENT VARIETIES AND SEEDING RA	ISION TURF SPE	

SEEDING RATES

TEMPORARY EROSION CONTROL NOTES

- 1. THE SMALLEST PRACTICAL AREA OF LAND SHALL BE EXPOSED AT ANY ONE TIME. AT NO TIME SHALL AN AREA IN EXCESS OF THAT REQUIRED FOR CONSTRUCTION BE EXPOSED.
- 2. EROSION, SEDIMENT AND DETENTION MEASURES SHALL BE INSTALLED AS SHOWN ON THE PLANS AND AT LOCATIONS AS REQUIRED OR DIRECTED BY THE ENGINEER.
- 3. ALL DISTURBED AREAS (INCLUDING POND AREAS BELOW THE PROPOSED WATERLINE) SHALL BE RETURNED TO PROPOSED GRADES AND ELEVATIONS. DISTURBED AREAS SHALL BE LOAMED WITH A MINIMUM OF 6" OF SCREENED ORGANIC LOAM AND SEEDED WITH SEED MIXTURE 'C' AT A RATE NOT LESS THAN 1.10 POUNDS OF SEED PER 1,000 S.F. OF AREA (48 LBS. / ACRE).
- 4. SILT FENCES AND OTHER BARRIERS SHALL BE INSPECTED EVERY SEVEN CALENDAR DAYS AND WITHIN 24 HOURS OF A RAINFALL OF 0.5" OR GREATER. ALL DAMAGED AREAS SHALL BE REPAIRED, AND SEDIMENT DEPOSITS SHALL PERIODICALLY BE REMOVED AND
- AFTER ALL DISTURBED AREAS HAVE BEEN STABILIZED, THE TEMPORARY EROSION CONTROL MEASURES SHALL BE REMOVED AND THE AREA DISTURBED BY THE REMOVAL SMOOTHED AND REVEGETATED.
- 6. AREAS MUST BE SEEDED AND MULCHED OR OTHERWISE PERMANENTLY STABILIZED WITHIN 3 DAYS OF FINAL GRADING, OR TEMPORARILY STABILIZED WITHIN 14 DAYS OF THE INITIAL DISTURBANCE OF SOIL.
- 7. ALL PROPOSED VEGETATED AREAS THAT DO NOT EXHIBIT A MINIMUM OF 85 PERCENT VEGETATIVE GROWTH BY OCTOBER 15, OR WHICH ARE DISTURBED AFTER OCTOBER 15, SHALL BE STABILIZED BY SEEDING AND INSTALLING NORTH AMERICAN GREEN S75 EROSION CONTROL BLANKETS (OR AN EQUIVALENT APPROVED IN WRITING BY THE ENGINEER) ON SLOPES GREATER THAN 3:1. AND SEEDING AND PLACING 3 TO 4 TONS OF MULCH PER ACRE, SECURED WITH ANCHORED NETTING, ELSEWHERE. THE INSTALLATION OF EROSION CONTROL BLANKETS OR MULCH AND NETTING SHALL NOT OCCUR OVER ACCUMULATED SNOW OR ON FROZEN GROUND AND SHALL BE COMPLETED IN ADVANCE OF THAW OR SPRING MELT EVENTS.
- ALL DITCHES OR SWALES WHICH DO NOT EXHIBIT A MINIMUM OF 85 PERCENT VEGETATIVE GROWTH BY OCTOBER 15, OR WHICH ARE DISTURBED AFTER OCTOBER 15, SHALL BE STABILIZED TEMPORARILY WITH STONE OR EROSION CONTROL BLANKETS APPROPRIATE
- 9. AFTER NOVEMBER 15th, INCOMPLETE ROAD OR PARKING SURFACES, WHERE WORK HAS STOPPED FOR THE WINTER SEASON. SHALL BE PROTECTED WITH A MINIMUM OF 3" OF CRUSHED GRAVEL PER NHDOT ITEM 304.3.
- 10. AN AREA SHALL BE CONSIDERED STABLE IF ONE OF THE FOLLOWING HAS OCCURRED:
- A. BASE COURSE GRAVELS HAVE BEEN INSTALLED IN AREAS TO BE PAVED; B. A MINIMUM OF 85% VEGETATED GROWTH HAS BEEN ESTABLISHED;
- C. A MINIMUM OF 3" OF NON-EROSIVE MATERIAL SUCH STONE OR RIPRAP HAS BEEN INSTALLED; OR D. EROSION CONTROL BLANKETS HAVE BEEN PROPERLY INSTALLED.
- 11. IN ORDER TO ENSURE THE STABILITY OF THE SITE AND EFFECTIVE IMPLEMENTATION OF THE SEDIMENT AND EROSION CONTROL MEASURES SPECIFIED IN THE PLANS FOR THE DURATION OF CONSTRUCTION, THE CONTRACTOR SHALL BE IN STRICT COMPLIANCE WITH THE FOLLOWING INSPECTION AND MAINTENANCE REQUIREMENTS IN ADDITION TO THOSE CALLED FOR IN THE SWPPP:
- A. A CERTIFIED PROFESSIONAL IN EROSION AND SEDIMENT CONTROL OR A PROFESSIONAL ENGINEER LICENSED IN THE STATE OF NEW HAMPSHIRE ("MONITOR") SHALL BE EMPLOYED TO INSPECT THE SITE FROM THE START OF ALTERATION OF TERRAIN ACTIVITIES UNTIL THE SITE IS IN FULL COMPLIANCE WITH THE ALTERATION OF TERRAIN PERMIT ("PERMIT").
- B. DURING THIS PERIOD, THE MONITOR SHALL INSPECT THE SUBJECT SITE AT LEAST ONCE A WEEK, AND IF POSSIBLE, DURING ANY 1/2 INCH OR GREATER RAIN EVENT (I.E. 1/2 INCH OF PRECIPITATION OR MORE WITHIN A 24 HOUR PERIOD). IF UNABLE TO BE PRESENT DURING SUCH A STORM, THE MONITOR SHALL INSPECT THE SITE WITHIN 24 HOURS OF THIS EVENT.
- THE MONITOR SHALL PROVIDE TECHNICAL ASSISTANCE AND RECOMMENDATIONS TO THE CONTRACTOR ON THE APPROPRIATE BEST MANAGEMENT PRACTICES FOR EROSION AND SEDIMENT CONTROLS REQUIRED TO MEET THE REQUIREMENTS OF RSA 485 A:17 AND ALL APPLICABLE DES PERMIT CONDITIONS.
- D. WITHIN 24 HOURS OF EACH INSPECTION, THE MONITOR SHALL SUBMIT A REPORT TO DES VIA EMAIL (RIDGELY MAUCK AT: RIDGELY.MAUCK@DES.NH.GOV).
- E. THE MONITOR SHALL MEET WITH DES TO DECIDE UPON A REPORT FORMAT. THE REPORT FORMAT SHALL BE REVIEWED AND APPROVED BY DES PRIOR TO THE START OF CONSTRUCTION.
- F. PRIOR TO BEGINNING CONSTRUCTION, THE CONTRACTOR'S NAME, ADDRESS, AND PHONE NUMBER SHALL BE SUBMITTED TO DES VIA EMAIL (SEE ABOVE).
- G. PRIOR TO CONSTRUCTION, A PHASING PLAN THAT DELINEATES EACH PHASE OF THE PROJECT SHALL BE SUBMITTED. ALL TEMPORARY SEDIMENT BASINS THAT WILL BE NEEDED FOR DEWATERING WORK AREAS SHALL BE LOCATED AND IDENTIFIED ON

CONSTRUCTION SEQUENCE

- 1. PRIOR TO THE START OF ANY ACTIVITY, IT IS THE RESPONSIBILITY OF THE SITE'S SITE DEVELOPER (OR OWNER) TO FILE A NOTICE OF INTENT (NOI) FORM WITH THE ENVIRONMENTAL PROTECTION AGENCY (EPA) IN ORDER TO GAIN COVERAGE UNDER THE NPDES GENERAL PERMIT FOR STORM WATER DISCHARGES FROM CONSTRUCTION ACTIVITIES. A PRE CONSTRUCTION MEETING IS TO BE HELD WITH ALL DEPARTMENT HEADS PRIOR TO THE START OF CONSTRUCTION.
- WETLAND BOUNDARIES ARE TO BE CLEARLY MARKED PRIOR TO THE START OF CONSTRUCTION. AT LEAST A TEMPORARY CULVERT OR ROADBED TO BE IN PLACE PRIOR TO THE START OF CONSTRUCTION.
- CUT AND REMOVE TREES IN CONSTRUCTION AREA AS REQUIRED OR DIRECTED.
- INSTALL SILT FENCING, HAY BALES AND CONSTRUCTION ENTRANCES PRIOR TO THE START OF CONSTRUCTION. THESE ARE TO BE MAINTAINED UNTIL THE FINAL PAVEMENT SURFACING AND LANDSCAPING AREAS ARE ESTABLISHED.
- 5. CLEAR, CUT, GRUB AND DISPOSE OF DEBRIS IN APPROVED FACILITIES. THIS INCLUDES ANY REQUIRED DEMOLITION OF EXISTING
- 6. CONSTRUCT AND/OR INSTALL TEMPORARY OR PERMANENT SEDIMENT AND/OR DETENTION BASIN(S) AS REQUIRED. THESE FACILITIES SHALL BE INSTALLED AND STABILIZED PRIOR TO DIRECTING RUN-OFF TO THEM.
- 7. STRIP LOAM AND PAVEMENT, OR RECLAIM EXISTING PAVEMENT WITHIN LIMITS OF WORK PER THE RECOMMENDATIONS OF THE PROJECT ENGINEER AND STOCKPILE EXCESS MATERIAL. STABILIZE STOCKPILE AS NECESSARY.
- 8. PERFORM PRELIMINARY SITE GRADING IN ACCORDANCE WITH THE PLANS, INCLUDING THE CONSTRUCTION OF ANY RETAINING WALLS
- 9. PREPARE BUILDING PAD(S) TO ENABLE BUILDING CONSTRUCTION TO BEGIN.
- 10. INSTALL THE SEWER AND DRAINAGE SYSTEMS FIRST, THEN ANY OTHER UTILITIES IN ACCORDANCE WITH THE PLAN AND DETAILS. ANY CONFLICTS BETWEEN UTILITIES ARE TO BE RESOLVED WITH THE INVOLVEMENT AND APPROVAL OF THE ENGINEER.
- 11. INSTALL INLET PROTECTION AT ALL CATCH BASINS AS THEY ARE CONSTRUCTED IN ACCORDANCE WITH DETAILS.
- 12. ALL SWALES AND DRAINAGE STRUCTURES ARE TO BE CONSTRUCTED AND STABILIZED PRIOR TO HAVING RUN-OFF DIRECTED TO THEM.
- 13. DAILY, OR AS REQUIRED, CONSTRUCT TEMPORARY BERMS, DRAINAGE DITCHES, CHECK DAMS, SEDIMENT TRAPS, ETC., TO PREVENT EROSION ON THE SITE AND PREVENT ANY SILTATION OF ABUTTING WATERS AND/OR PROPERTY.
- 14. PERFORM FINAL FINE GRADING, INCLUDING PLACEMENT OF 'SELECT' SUBGRADE MATERIALS.
- 15. PAVE ALL PARKING LOTS AND ROADWAYS WITH INITIAL 'BASE COURSE'.
- 16. PERFORM ALL REMAINING SITE CONSTRUCTION (i.e. BUILDING, CURBING, UTILITY CONNECTIONS, ETC.).
- 17. LOAM AND SEED ALL DISTURBED AREAS AND INSTALL ANY REQUIRED SEDIMENT AND EROSION CONTROL FACILITIES (i.e. RIP RAP, EROSION CONTROL BLANKETS, ETC.).
- 18. FINISH PAVING ALL ROADWAYS AND PARKING AREAS WITH 'FINISH' COURSE.
- 19. ALL ROADWAYS AND PARKING LOTS SHALL BE STABILIZED WITHIN 72 HOURS OF ACHIEVING FINISHED GRADE.
- 20. ALL CUT AND FILL SLOPES SHALL BE SEEDED/LOAMED WITHIN 72 HOURS OF ACHIEVING FINISHED GRADE.
- 21. COMPLETE PERMANENT SEEDING AND LANDSCAPING.
- 22. REMOVE TEMPORARY EROSION CONTROL MEASURES AFTER SEEDING AREAS HAVE BEEN 75%-85% ESTABLISHED AND SITE IMPROVEMENTS ARE COMPLETE. SMOOTH AND RE-VEGETATE ALL DISTURBED AREAS.
- 23. CLEAN SITE AND ALL DRAINAGE STRUCTURES, PIPES AND SUMPS OF ALL SILT AND DEBRIS.
- 24. INSTALL ALL PAINTED PAVEMENT MARKINGS AND SIGNAGE PER THE PLANS AND DETAILS.
- 25. ALL EROSION CONTROLS SHALL BE INSPECTED WEEKLY AND AFTER EVERY HALF-INCH OF RAINFALL.
- 26. UPON COMPLETION OF CONSTRUCTION, IT IS THE RESPONSIBILITY OF THE CONTRACTOR TO NOTIFY ANY RELEVANT PERMITTING

AGENCIES THAT THE CONSTRUCTION HAS BEEN FINISHED IN A SATISFACTORY MANNER.


Designed and Produced in NH Jones & Beach Engineers, Inc.

Civil Engineering Services 603-772-4746 FAX: 603-772-0227 E-MAIL: JBE@JONESANDBEACH.COM

	Plan Name:	EROSION AND SEDIMENT CONTROL DETAILS
	Project:	4-BAY CAR SERVICE 3 DOVER ROAD, ROUTE 108, DURHAM, NH
,	Applicant:	TROPIC STAR DEVELOPMENT, LLC 321D LAFAYETTE ROAD, HAMPTON, NH 03842

JBE PROJECT NO. 14011

DRAWING No.

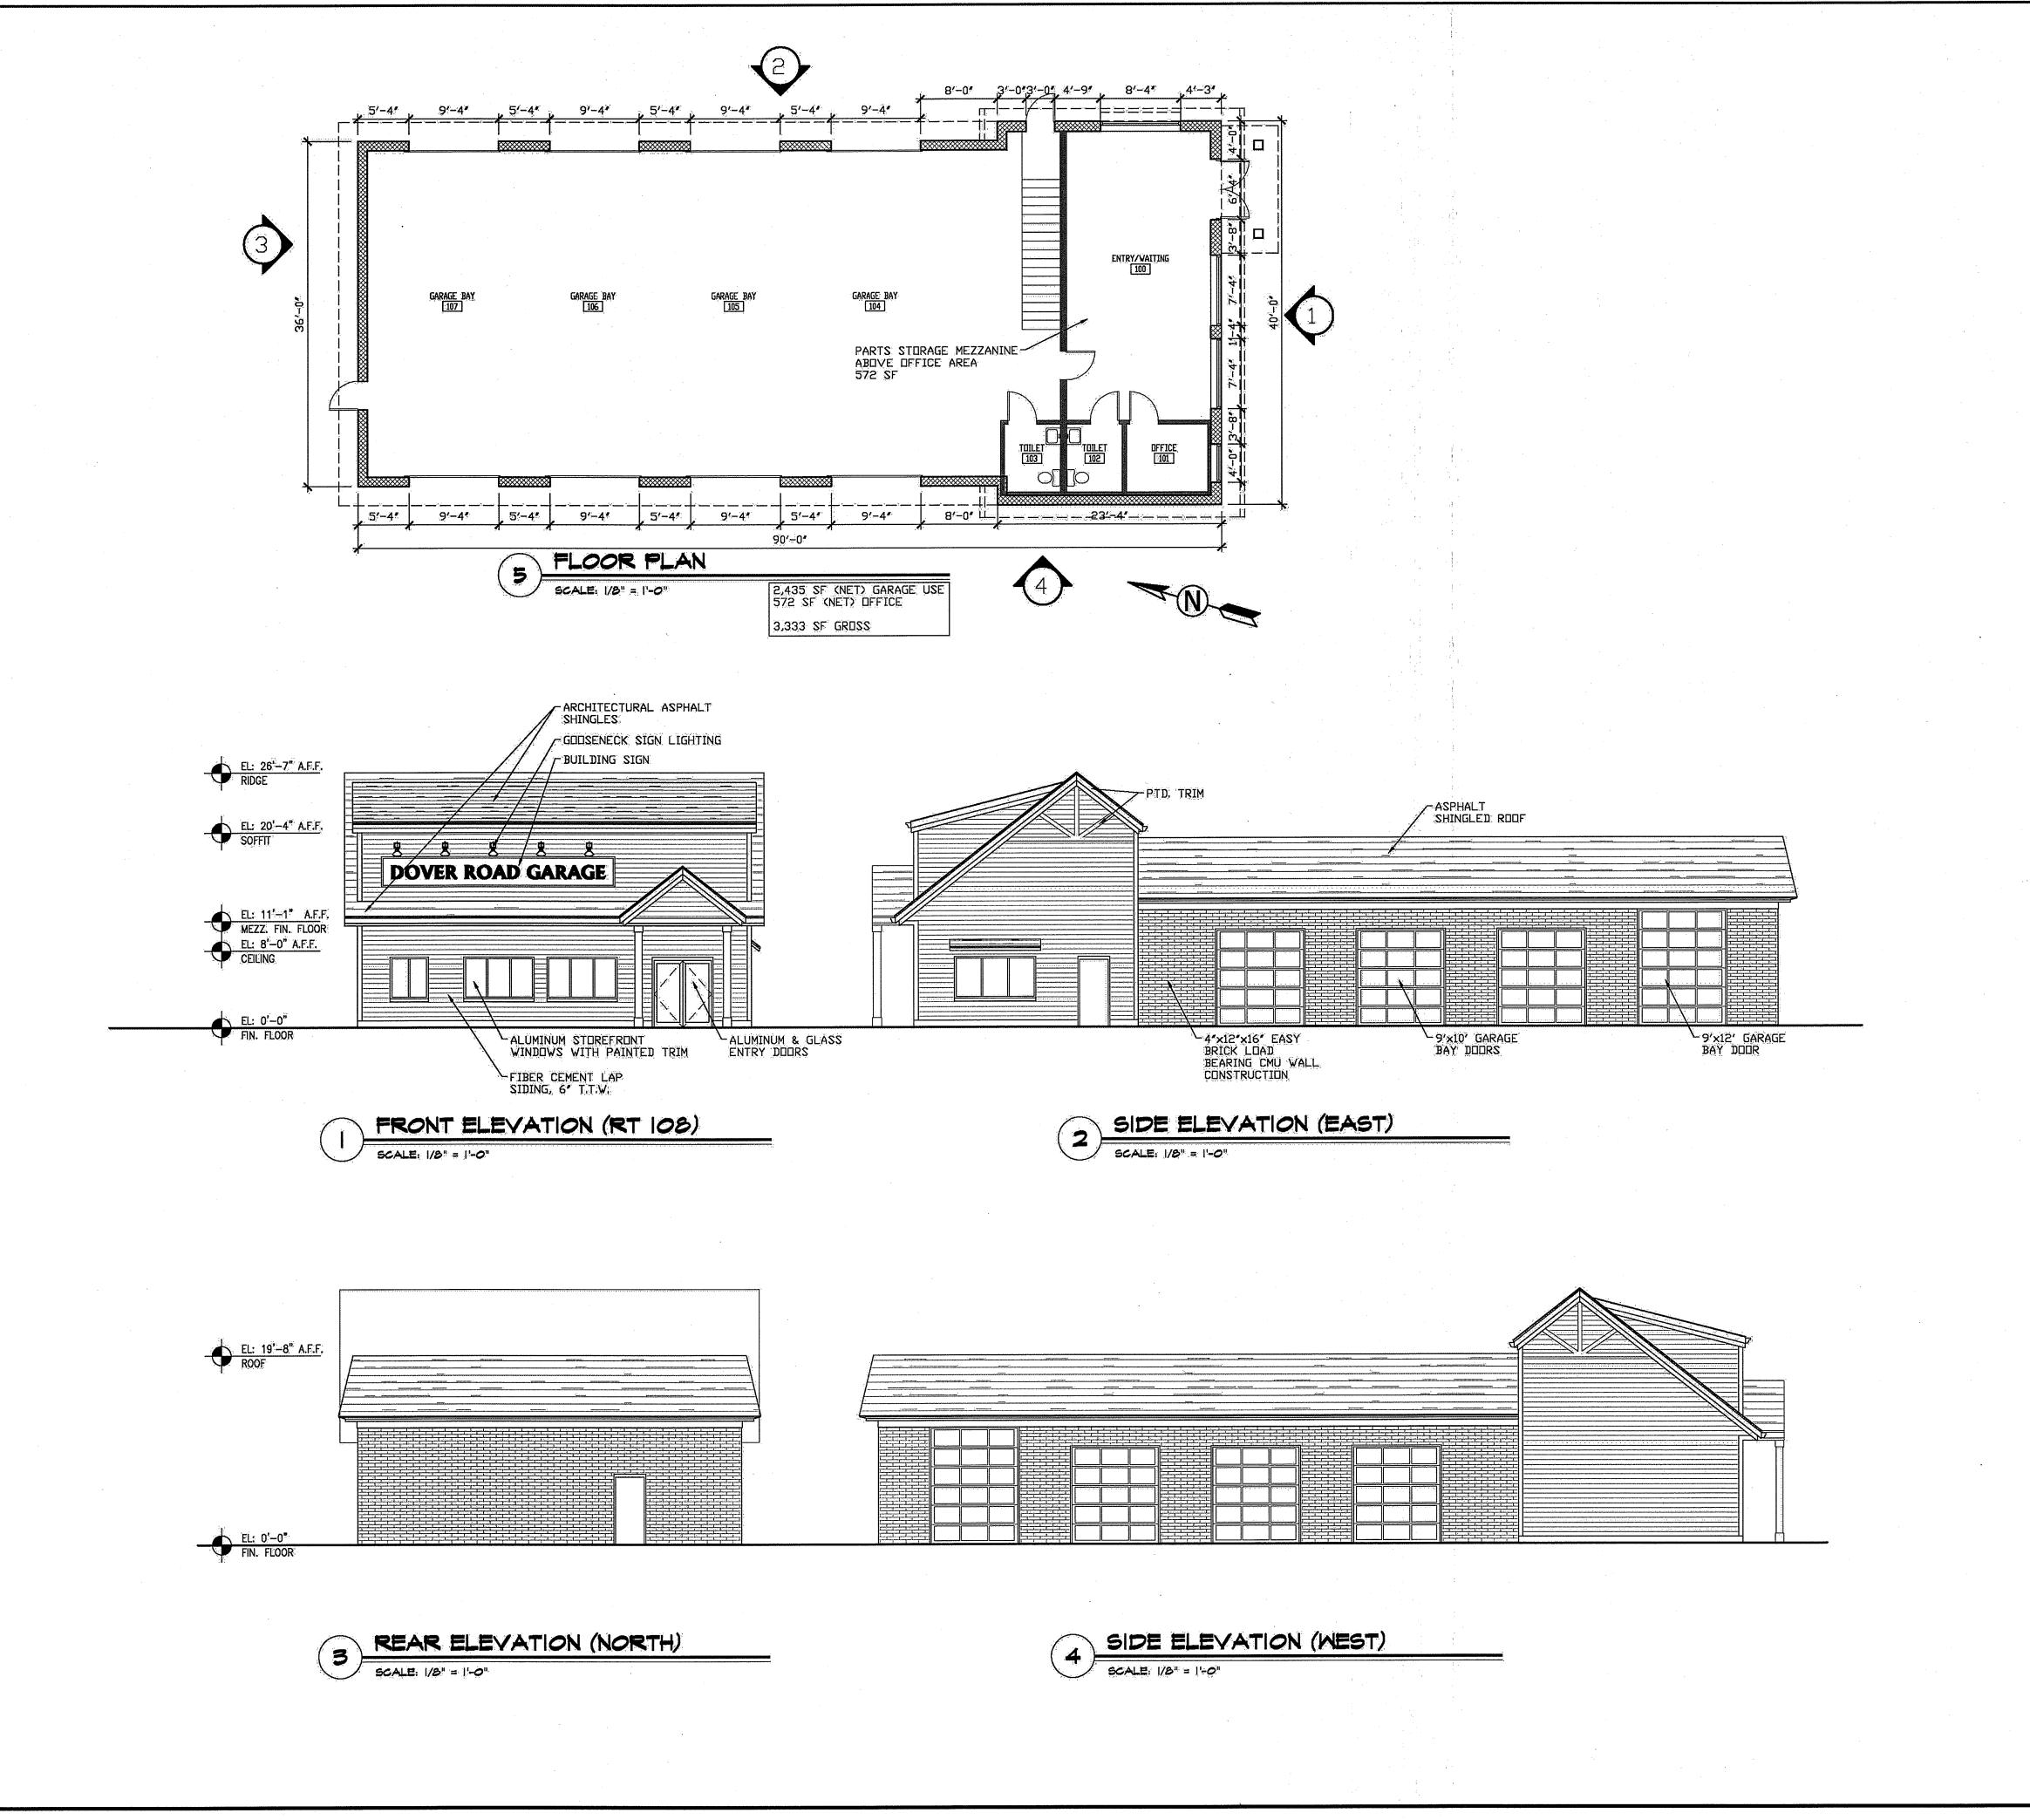

BKA Architects, Inc.

142 Creecent Street Brockton, MA 02302

e-mail : bka-bkaarche.com

tel:508.583,5603

ther than the specified project for which they have been prepared and developed, without the express knowledge on

MATIC PLAN & ELEVATIONS

MATIC PLAN & ELEVATIONS

DOVER ROAD CAR CARE

Scale: AS NOTED

Date: 6/3/14

Drawn By: JSG

Checked By: WHO?

Job Number: 21410T

Drawing:

AI